

CITY OF SANTA CRUZ, CALIFORNIA

GRAHAM HILL WATER TREATMENT PLANT


FACILITY IMPROVEMENTS PROJECT

ADMIN-OPS AND MAINTENANCE

BUILDINGS -

PLANNING DEPARTMENT

PERMITS PLAN SET

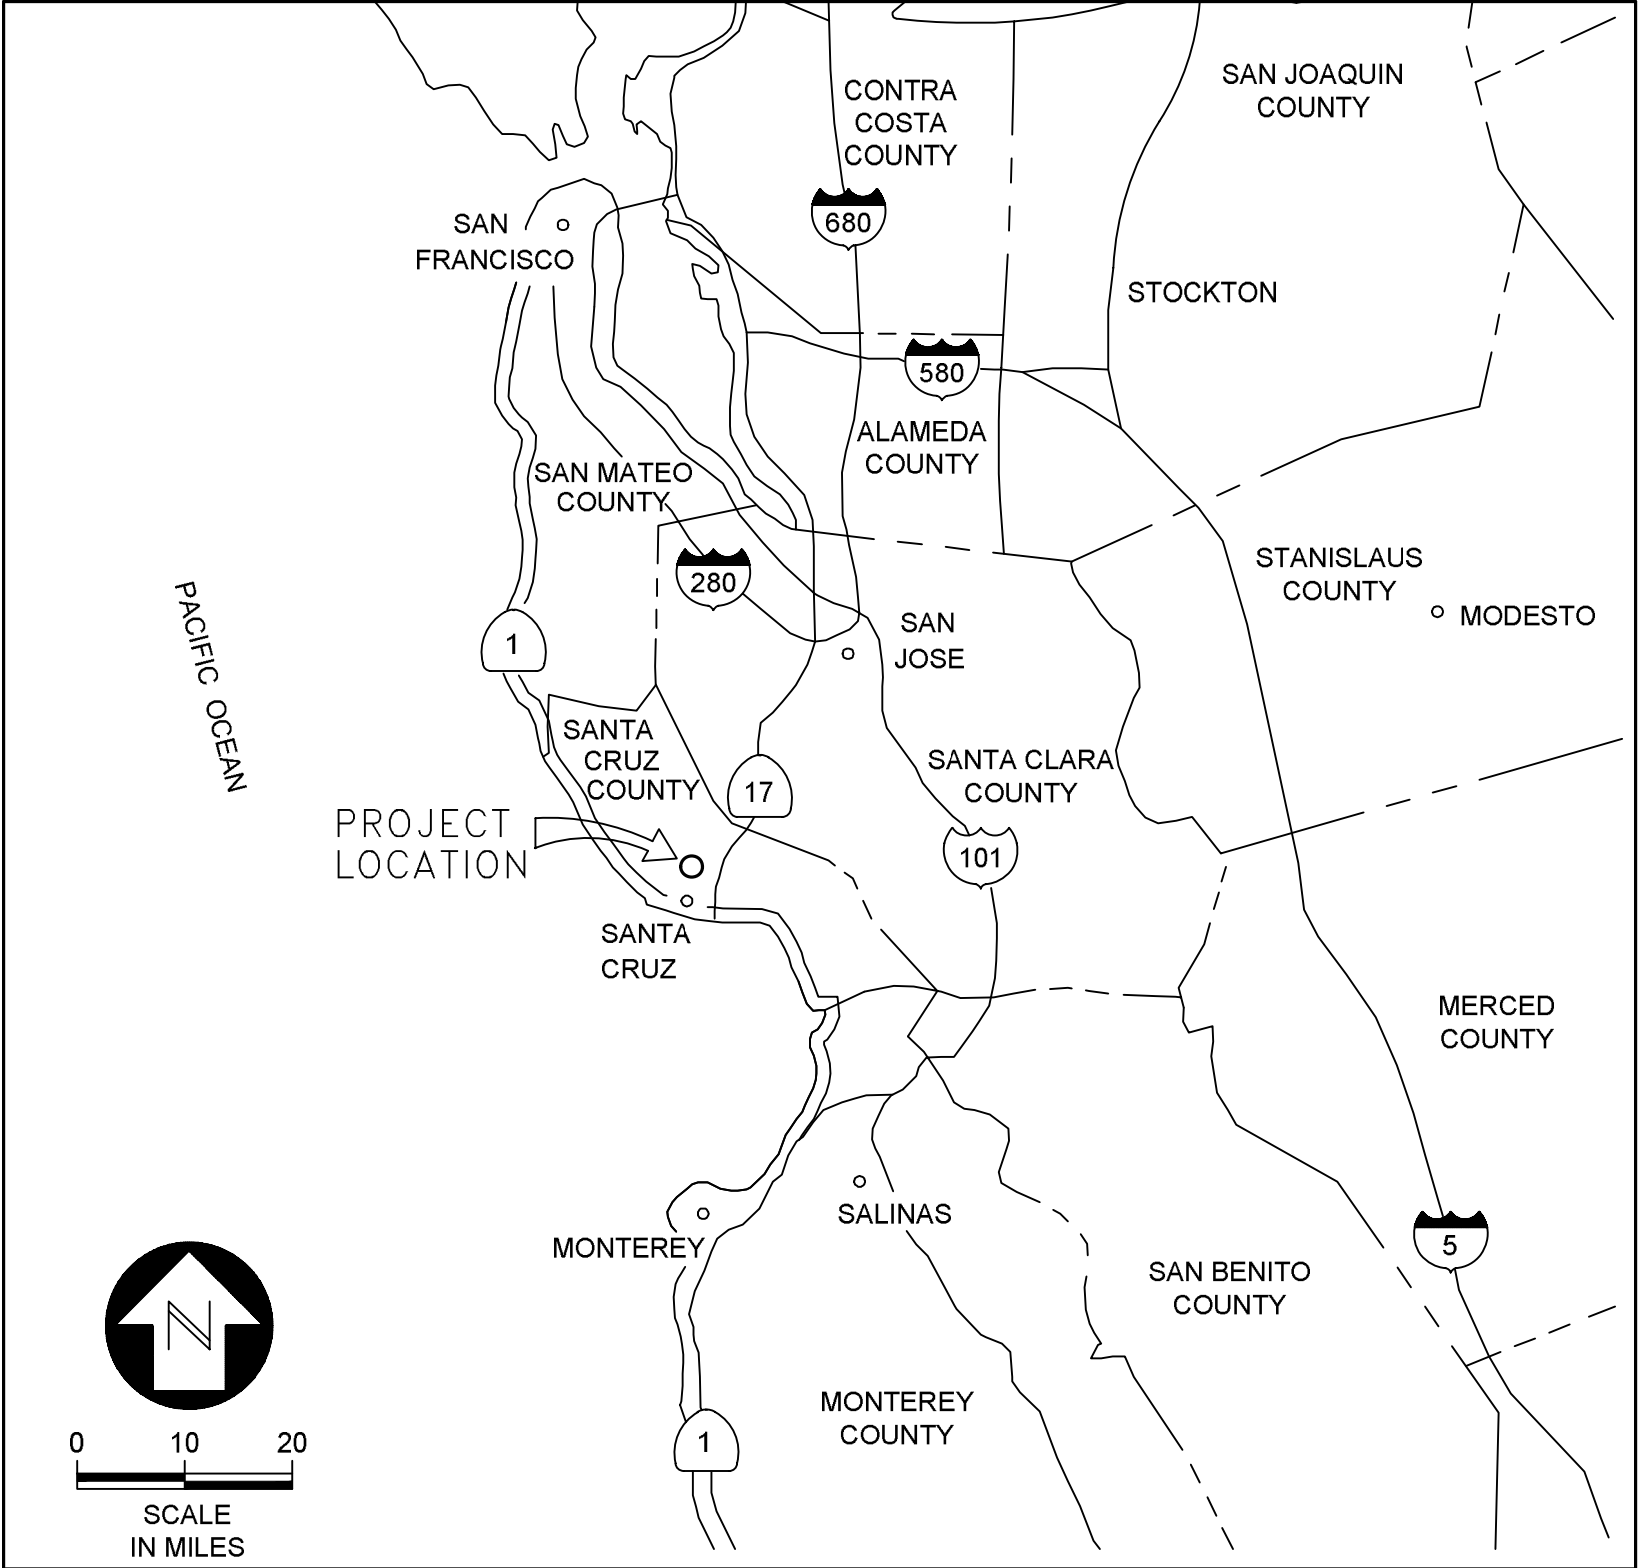

VICINITY MAP

DESCRIPTION

COVER SHEET

SITE PLAN

TOPOGRAPHIC MAP

FLOOR PLANS:

- ADMIN & OPS BUILDING FLOOR PLAN
- OPS BUILDING ENLARGED FLOOR PLAN
- ADMIN BUILDING ENLARGED FLOOR PLAN
- MAINTENANCE BUILDING FLOOR PLAN

ELEVATIONS:

- ADMIN & OPS BUILDING ELEVATION 1
- ADMIN & OPS BUILDING ELEVATION 2
- MAINTENANCE BUILDING ELEVATION

CONTEXT / BUILDING AND SITE SECTIONS

LANDSCAPE PLANS

ROOF PLANS:

- ADMIN & OPS BUILDING ROOF PLAN
- MAINTENANCE BUILDING ROOF PLAN

DEMOLITION PLANS

PRELIMINARY GRADING PLAN

WALL SECTIONS:

- ADMIN & OPS BUILDING SECTIONS 1
- ADMIN & OPS BUILDING SECTIONS 2
- ADMIN & OPS BUILDING WALL SECTIONS 1
- MAINTENANCE BUILDING - SECTIONS

MISCELLANEOUS ARCHITECTURAL DETAILS

INDEX OF DRAWINGS

PAGE #

1

2

3

4

5

6

7

8

9

10

11

12 - 14

15

16

17 - 20

21

22

23

24

25

26 - 27

FEBRUARY 2024

PROJECT

GRAHAM HILL WATER
TREATMENT PLANT - FACILITY
IMPROVEMENTS PROJECT
715 Graham Hill Rd,
Santa Cruz, CA 95060
APN 060-141-05

OWNER

CITY OF SANTA CRUZ
WATER DEPARTMENT
212 Locust St Ste A,
Santa Cruz, CA 95060
Phone: (831) 420-520C



ENGINEER

AECOM TECHNICAL SERVICES, INC.
250 APOLLO DRIVE
CHELMSFORD, MA 01824
PHONE: (978) 905-2100
www.aecom.com

AECOM TECHNICAL SERVICES, INC.
2020 L STREET
SACRAMENTO, CA 95811
PHONE: (916) 414-5800
www.aecom.com

CONSULTANTS

KENNEDY JENKS (Design Assistance)
275 Battery Street, Suite 550
San Francisco, CA 94111
www.kennedyjenks.com

BOWMAN & WILLIAMS (Surveyor)
3949 Research Park Court, Suite 100
Soquel, CA 95073
www.bowmanandwilliams.com

REGISTRATION



ISSUE/REVISION

I/R	DATE	DESCRIPTION

PROJECT NUMBER

60667213

Designed By:	L. HAYROYAN
Drawn By:	L. HAYROYAN
Dept Check:	N/A
Proj Check:	G. PERIGAULT
Date:	DECEMBER 2023
Scale:	AS NOTED


DISCIPLINE

GENERAL
SHEET TITLE

COVER SHEET

SHEET NUMBER

00-G-001 PAGE 1 OF 27

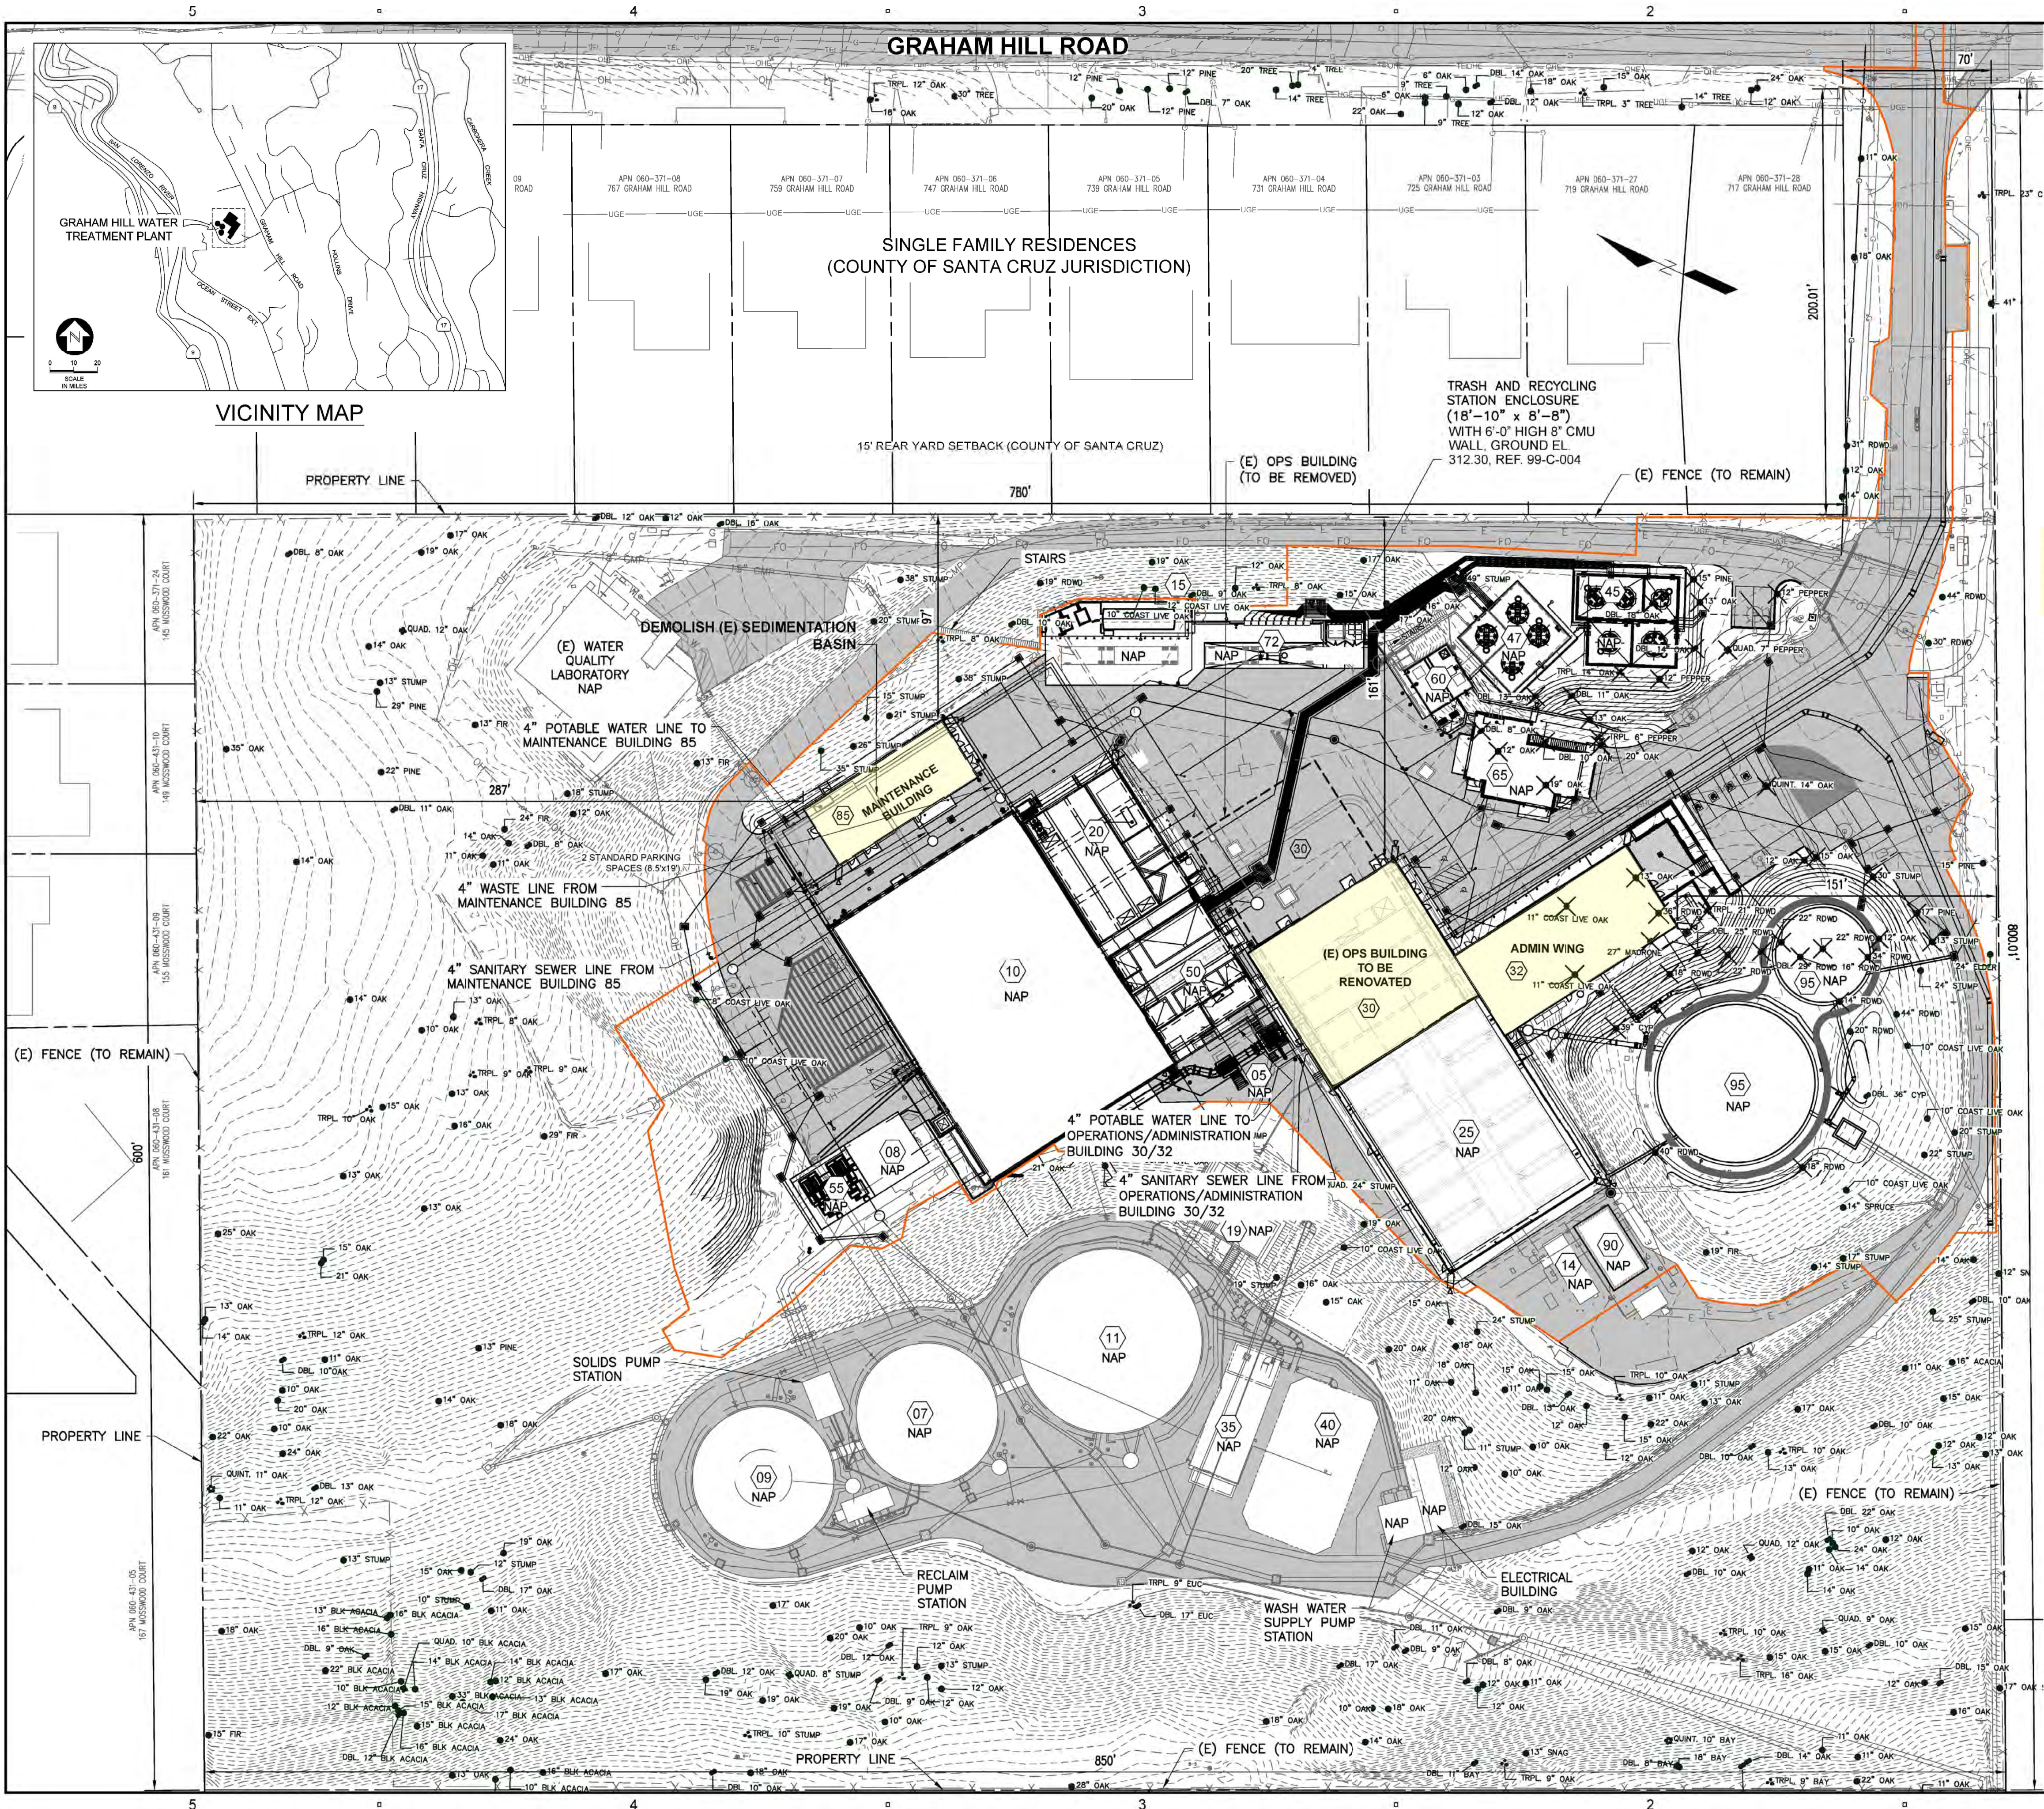

LEGEND

TREE LOCATION
(FROM SITE PLAN - KEY MAP SHEET 00-C-100 DECEMBER 2022)

REMOVE TREE

CONSTRUCTION LIMITS

PROPERTY LINE

FENCE LINE

PROPOSED CONTOURS

EXISTING CONTOURS

ROADWAY LUMINAIRE

BUILDING/STRUCTURE THAT IS NOT A PART OF PLANNING PERMIT

NOTES

1. BUILDING SETBACK (SIDE YARD) - 10 FEET.

2. SEE SITE PIPING PLANS FOR DETAILED INFORMATION ON EXISTING AND PROPOSED UTILITIES.

STRUCTURE DESIGNATION

STRUCTURES FOR PLANNING DEPT. REVIEW:

30

OPERATIONS BUILDING (EXISTING)

32

ADMINISTRATION BUILDING (PROPOSED)

85

MAINTENANCE BUILDING (PROPOSED)

STRUCTURES NOT A PART OF PERMIT (NAP):

EXISTING STRUCTURES & USES:

07

RECLAIM TANK (EXISTING) - NAP

08

LAMELLA CLARIFIERS (EXISTING) - NAP

09

SOLIDS STORAGE TANK (EXISTING) - NAP

10

SEDIMENTATION BASINS (EXISTING) - NAP

11

TREATED WATER STORAGE TANK (EXISTING) - NAP

14

STAND-BY GENERATOR (EXISTING) - NAP

19

FILTERED WATER TANK INLET STRUCTURE (EXISTING) - NAP

25

FILTERS BUILDING (EXISTING) - NAP

47

CHEMICAL STORAGE (EXISTING) - NAP

90

ELECTRICAL BUILDING (EXISTING) - NAP

PROPOSED STRUCTURES:

05

RAPID AND INDUCTION MIXING STRUCTURES - NAP

15

LOX TANK AND VAPORIZERS - NAP

20

OZONE BUILDING - NAP

35

GAC INFLUENT PUMP STATION (FUTURE) - NAP

40

GAC ADSORBERS (FUTURE) - NAP

42

UV FACILITY (FUTURE) - NAP

45

CHEMICAL STORAGE - NAP

50

CHEMICAL DAY TANKS BUILDING - NAP

55

LAMELLA CLARIFIERS - NAP

60

THICKENED SOLIDS EQUALIZATION TANK AND PUMPING STATION - NAP

65

DEWATERING BUILDING - NAP

72

CHEMICAL UNLOADING PAD - NAP

95

WASH WATER STORAGE TANKS - NAP

PARKING SUMMARY:

STANDARD SPACES (10'x19')

=> 5

STANDARD SPACES (9'x19')

=> 2

STANDARD SPACES (8.5'x19')

=> 19

ADA SPACES (9.5'x19')

=> 2

ADA SPACE (8.5'x19')

=> 1

COMPACT SPACES (9'x18')

=> 13

COMPACT SPACES (7.5'x16')

=> 1

TOTAL PARKING SPACES

=> 43

AECOM W.M. LYLES CO.

a joint venture

PROJECT

GRAHAM HILL WATER TREATMENT PLANT - FACILITY IMPROVEMENTS PROJECT

715 Graham Hill Rd,
Santa Cruz, CA 95060
APN 060-141-05

OWNER

CITY OF SANTA CRUZ WATER DEPARTMENT

212 Locust St Ste A,
Santa Cruz, CA 95060
Phone: (831) 420-5200

ENGINEER

AECOM TECHNICAL SERVICES, INC.
250 APOLLO DRIVE
CHELMSFORD, MA 01824
PHONE: (978) 905-2100
www.aecom.com

AECOM TECHNICAL SERVICES, INC.
2020 L STREET
SACRAMENTO, CA 95811
PHONE: (916) 414-5800
www.aecom.com

CONSULTANTS

KENNEDY JENKS (Design Assistance)
275 Battery Street, Suite 550
San Francisco, CA 94111
www.kennedyjenks.com

BOWMAN & WILLIAMS (Surveyor)
3949 Research Park Court, Suite 100
Soquel, CA 95073
www.bowmanandwilliams.com

REGISTRATION

ISSUE/REVISION

I/R	DATE	DESCRIPTION

PROJECT NUMBER

60667213

Designed By:	BB
Drawn By:	AR
Dept Check:	LR
Proj Check:	G. PERIGAUULT
Date:	JANUARY 2024
Scale:	1" = 40'

DISCIPLINE

CIVIL

SHEET TITLE

PLANNING SUBMITTAL

SITE PLAN

SHEET NUMBER

00-C-100-P PAGE 2 OF 27

5 4 3 2 1


D

C

B

A

PATH: \\C:\Users\RAD\OneDrive\AECOM\60667213-GHWP-FIP\PROJECT FILES\910CAD_BIM\20 SHEETS\00-C-113-C-123.DWG
LAST UPDATE: 12/15/2023 9:31:04 PM
PLOT DATE: 11/02/2024 11:31:25 AM

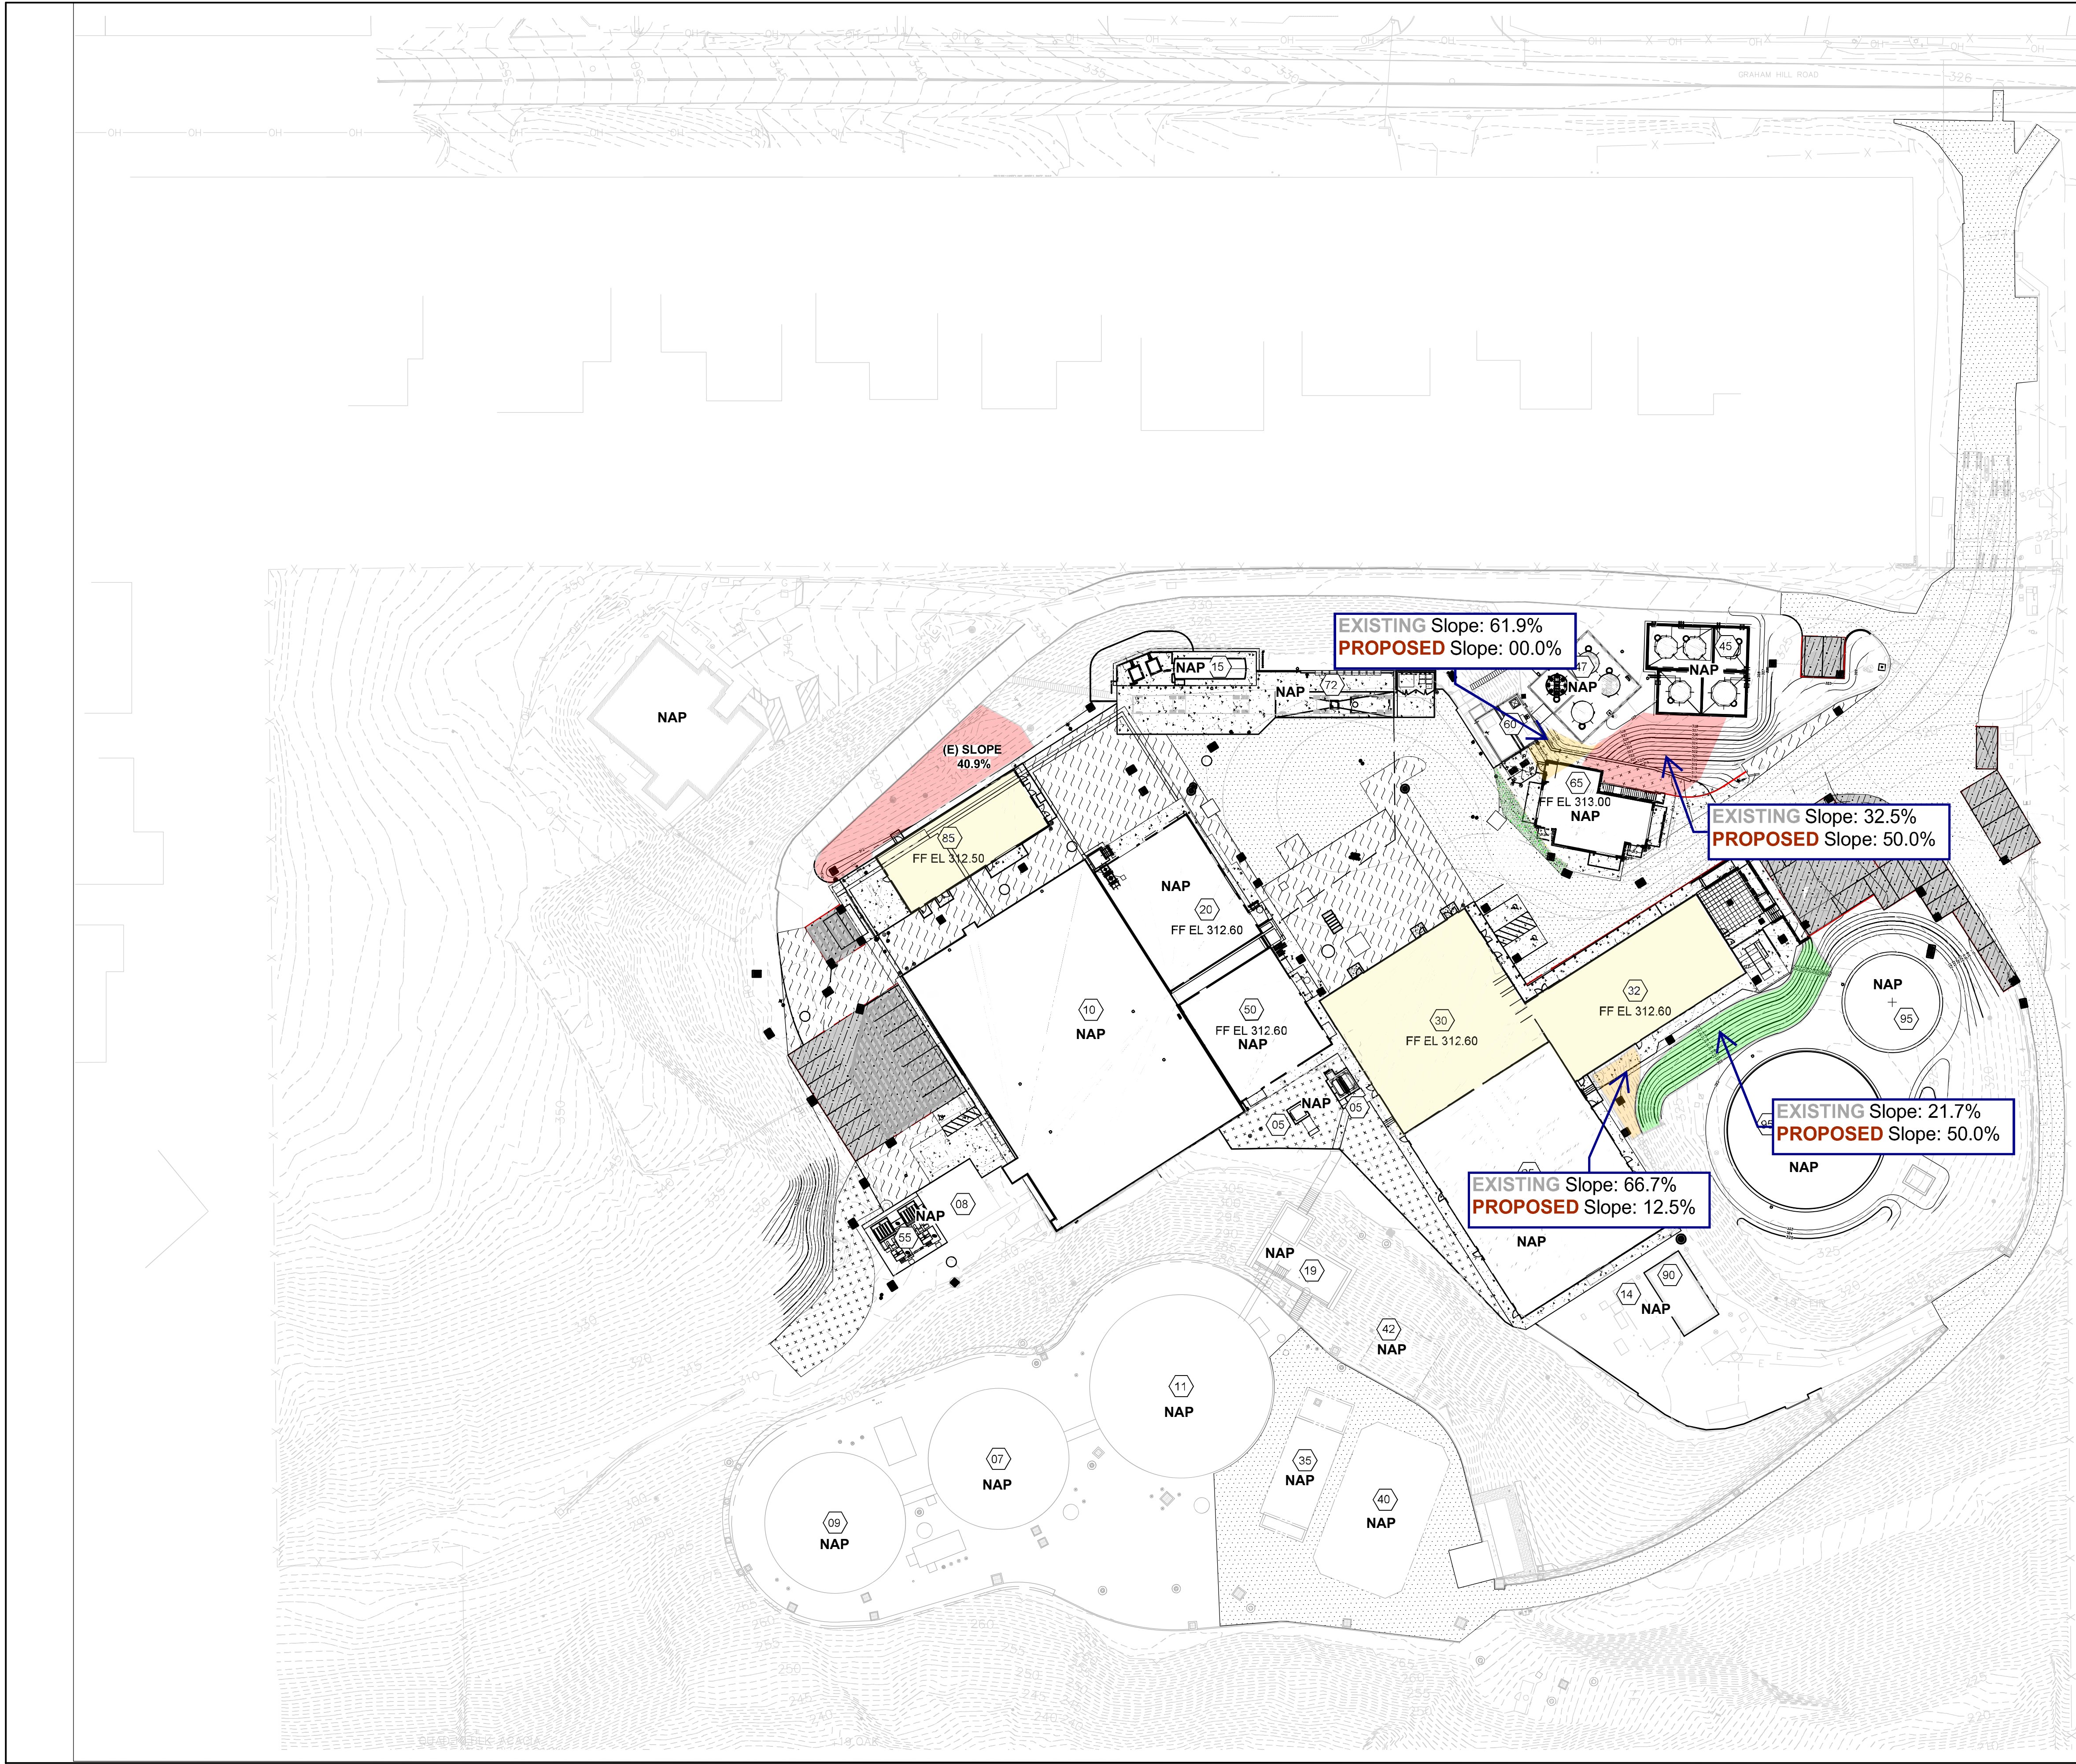

- LEGEND**
- GRIND/REMOVE AND OVERLAY AC (3") (TI = 6.5)
 - NEW POROUS AC (4") OVER 4" PERM AB OVER 18" BALLAST (TI = 5)
 - NEW AC (4") OVER AB (10") (TI = 6.5)
 - NEW REINFORCED CONCRETE (EQUIP PADS, ADA PARKING, SIDEWALKS, AND LANDINGS)
 - GRAVEL DRIVE
 - CONCRETE PAVERS
 - RIPRAP
 - NEW VERTICAL CURB (AT PARKING AND SIDEWALK)
 - NEW FLUSH CURB (PERIMETER OF POROUS AC)
 - AREA REQUIRING REGRADING FROM EXISTING TO MAKE PLANNED BUILDING FUNCTIONAL
 - PROPOSED CONTOURS
 - EXISTING CONTOURS
 - NAP** NOT A PART OF PERMIT
 - EXISTING 20% - 29% SLOPE
 - EXISTING 30% - 49% SLOPE
 - EXISTING 50%+ SLOPE
 - STRUCTURE TO BE PERMITTED
- NET LOT AREA - 1.5 ACRES
GROSS LOT AREA - 4.4 ACRES

SEE SITE PLAN FOR STRUCTURE DESIGNATION LEGEND

- NOTES:**
- SEE AREA DESIGNATION KEY PLAN ON SHEET 00-C-004 FOR STRUCTURE DESIGNATION.
 - ALL PERMANENT AND TEMPORARY STANDARD AND COMPACT SPACES TO HAVE 4" WIDE WHITE STRIPING.

PROJECT

GRAHAM HILL WATER TREATMENT PLANT - FACILITY IMPROVEMENTS PROJECT

715 Graham Hill Rd,
Santa Cruz, CA 95060
APN 060-141-05

OWNER

CITY OF SANTA CRUZ WATER DEPARTMENT

212 Locust St Ste A,
Santa Cruz, CA 95060
Phone: (831) 420-5200

ENGINEER


AECOM TECHNICAL SERVICES, INC.
250 APOLLO DRIVE
CHELMSFORD, MA 01824
PHONE: (978) 905-2100
www.aecom.com

AECOM TECHNICAL SERVICES, INC.
2020 L STREET
SACRAMENTO, CA 95811
PHONE: (916) 414-5800
www.aecom.com

CONSULTANTS

KENNEDY JENKS (Design Assistance)
275 Battery Street, Suite 550
San Francisco, CA 94111
www.kennedyjenks.com

BOWMAN & WILLIAMS (Surveyor)
3949 Research Park Court, Suite 100
Soquel, CA 95073
www.bowmanandwilliams.com

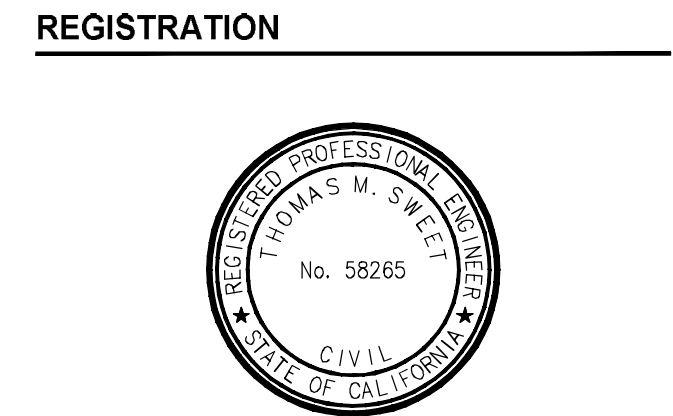

ISSUE/REVISION

I/R	DATE	DESCRIPTION

PROJECT NUMBER

60667213

Designed By:	WT
Drawn By:	MW
Dept Check:	LR
Proj Check:	G. PERIGAULT
Date:	DECEMBER 2023
Scale:	1" = 40'

DISCIPLINE

CIVIL

SHEET TITLE

TOPOGRAPHIC MAP

PROJECT

GRAHAM HILL WATER
TREATMENT PLANT - FACILITY
IMPROVEMENTS PROJECT

715 Graham Hill Rd,
Santa Cruz, CA 95060
APN 060-141-05

OWNER

**CITY OF SANTA CRUZ
WATER DEPARTMENT**

212 Locust St Ste A
Santa Cruz, CA 95060
PHONE: (831) 420-5200



ENGINEER

AECOM TECHNICAL SERVICES, INC.
250 APOLLO DRIVE
CHELMSFORD, MA 01824
PHONE: (978) 905-2100
www.aecom.com


AECOM TECHNICAL SERVICES, INC.
2020 L STREET
SACRAMENTO, CA 95811
PHONE: (916) 414-5800
www.aecom.com

CONSULTANTS

KENNEDY JENKS (Design assistance)
275 Battery Street, Suite 550
San Francisco, CA 94111
www.kennedyjenks.com

BOWMAN & WILLIAMS (Surveyor)
3949 Research Park Court, Suite 100
Soquel, CA 95073
www.bowmanandwilliams.com

REGISTRATION

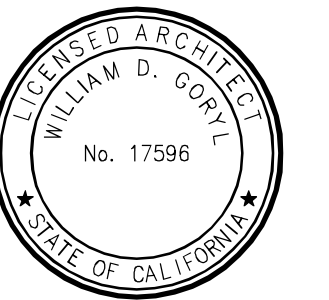

ISSUE/REVISION

NO.	DATE	DESCRIPTION

PROJECT NUMBER

60667213

Designed By:	W. GORYL
Drawn By:	M. PICONE
Dept Check:	G. OTTERSON
Approved by:	G. PERIGAULT
Date:	DECEMBER 2023
Scale:	As indicated

DISCIPLINE

ARCHITECTURAL
SHEET TITLE

**ADMIN & OPS BUILDING -
OVERALL GRADE LEVEL
FLOOR PLAN**
SHEET NUMBER

30-32 A-101 PAGE 4 OF 27

ADMIN & OPS BUILDING 1ST FLOOR

**TOTAL GROSS FLOOR AREA: 9,916 SF
(SEE DWGS. 30-32 A-102 & 30-32 A-103 FOR FLOOR PLAN DETAILS)**

**OPERATIONS
BUILDING
(OPS)**

ADMIN

**NOT PART OF PERMIT
SUBMITTAL**

**EXISTING FILTERS
BUILDING**

OVERALL GRADE LEVEL
Scale: 3/32" = 1'-0"



ROOM SCHEDULE					
NO.	DESCRIPTION	NO.	DESCRIPTION	NO.	DESCRIPTION
101	ENTRY	109	UNISEX RESTROOM	115	INSTRUMENTATION & CONTROL ROOM
102	STORAGE ROOM 1	110	MANAGEMENT ANALYST OFFICE 4	116	TOILET 2
103	CONFERENCE ROOM	111	NETWORK ADMINISTRATOR OFFICE 3	117	MECHANICAL ROOM 1
105	CORRIDOR	112	SUPERINTENDENT OFFICE	118	HALL 1
107	MECHANICAL ROOM 2	113	DEPUTY DIRECTOR OFFICE	119	TOILET 1
108	HALL 2	114	ELECTRIC ROOM		

KEYNOTE LEGEND	
KEY VALUE	KEYNOTE TEXT
03250.16	CONCRETE PAVERS
05000.25	BOLLARDS, SEE CIVIL DRAWINGS
06400.06	PLASTIC LAMINATE COUNTER AND BACKSPLASH
08350.02	MULTIPANEL FOLDING ALUMINUM FRAMED INSULATED FABRIC DOORS
10525.03	RECESSED FIRE EXTINGUISHER
12500.01	F-1 CONFERENCE ROOM TABLE
12500.03	F-3 MID-BACK DESK CHAIR(S)
13034.01	ACOUSTIC WALL
13120.01	PRE-ENGINEERED METAL STRUCTURE
13120.02	PRE-ENGINEERED METAL STRUCTURE CROSS BRACING
15100.01	MECHANICAL EQUIPMENT, SEE HVAC DRAWINGS
16050.02	ELECTRICAL EQUIPMENT, SEE ELECTRICAL DRAWINGS

AECOM **W.M. LYLES CO.**
a joint venture

PROJECT

GRAHAM HILL WATER TREATMENT PLANT - FACILITY IMPROVEMENTS PROJECT

715 Graham Hill Rd,
Santa Cruz, CA 95060
APN 060-141-05

OWNER

CITY OF SANTA CRUZ
WATER DEPARTMENT

212 Locust St Ste A
Santa Cruz, CA 95060
PHONE: (831) 420-5200

ENGINEER

AECOM TECHNICAL SERVICES, INC.
250 APOLLO DRIVE
CHELMSFORD, MA 01824
PHONE: (978) 905-2100
www.aecom.com


AECOM TECHNICAL SERVICES, INC.
2020 L STREET
SACRAMENTO, CA 95811
PHONE: (916) 414-5800
www.aecom.com

CONSULTANTS

KENNEDY JENKS (Design assistance)
275 Battery Street, Suit 550
San Francisco, CA 94111
www.kennedyjenks.com

BOWMAN & WILLIAMS (Surveyor)
3949 Research Park Court, Suite 100
Soquel, CA 95073
www.bowmanandwilliams.com

REGISTRATION

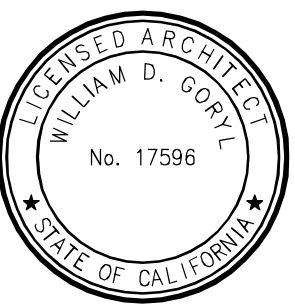

ISSUE/REVISION

I/R	DATE	DESCRIPTION

PROJECT NUMBER

60667213


Designed By:	W. GORYL
Drawn By:	M. PICONE
Dept Check:	G. OTTERSON
Approved by:	G. PERIGAUULT
Date:	DECEMBER 2023
Scale:	3/16" = 1'-0"

DISCIPLINE

ARCHITECTURAL
SHEET TITLE

**ADMIN & OPS BUILDING -
GRADE LEVEL
ENLARGED FLOOR PLAN 2
SHEET NUMBER**

30-32 A-103 PAGE 6 OF 27

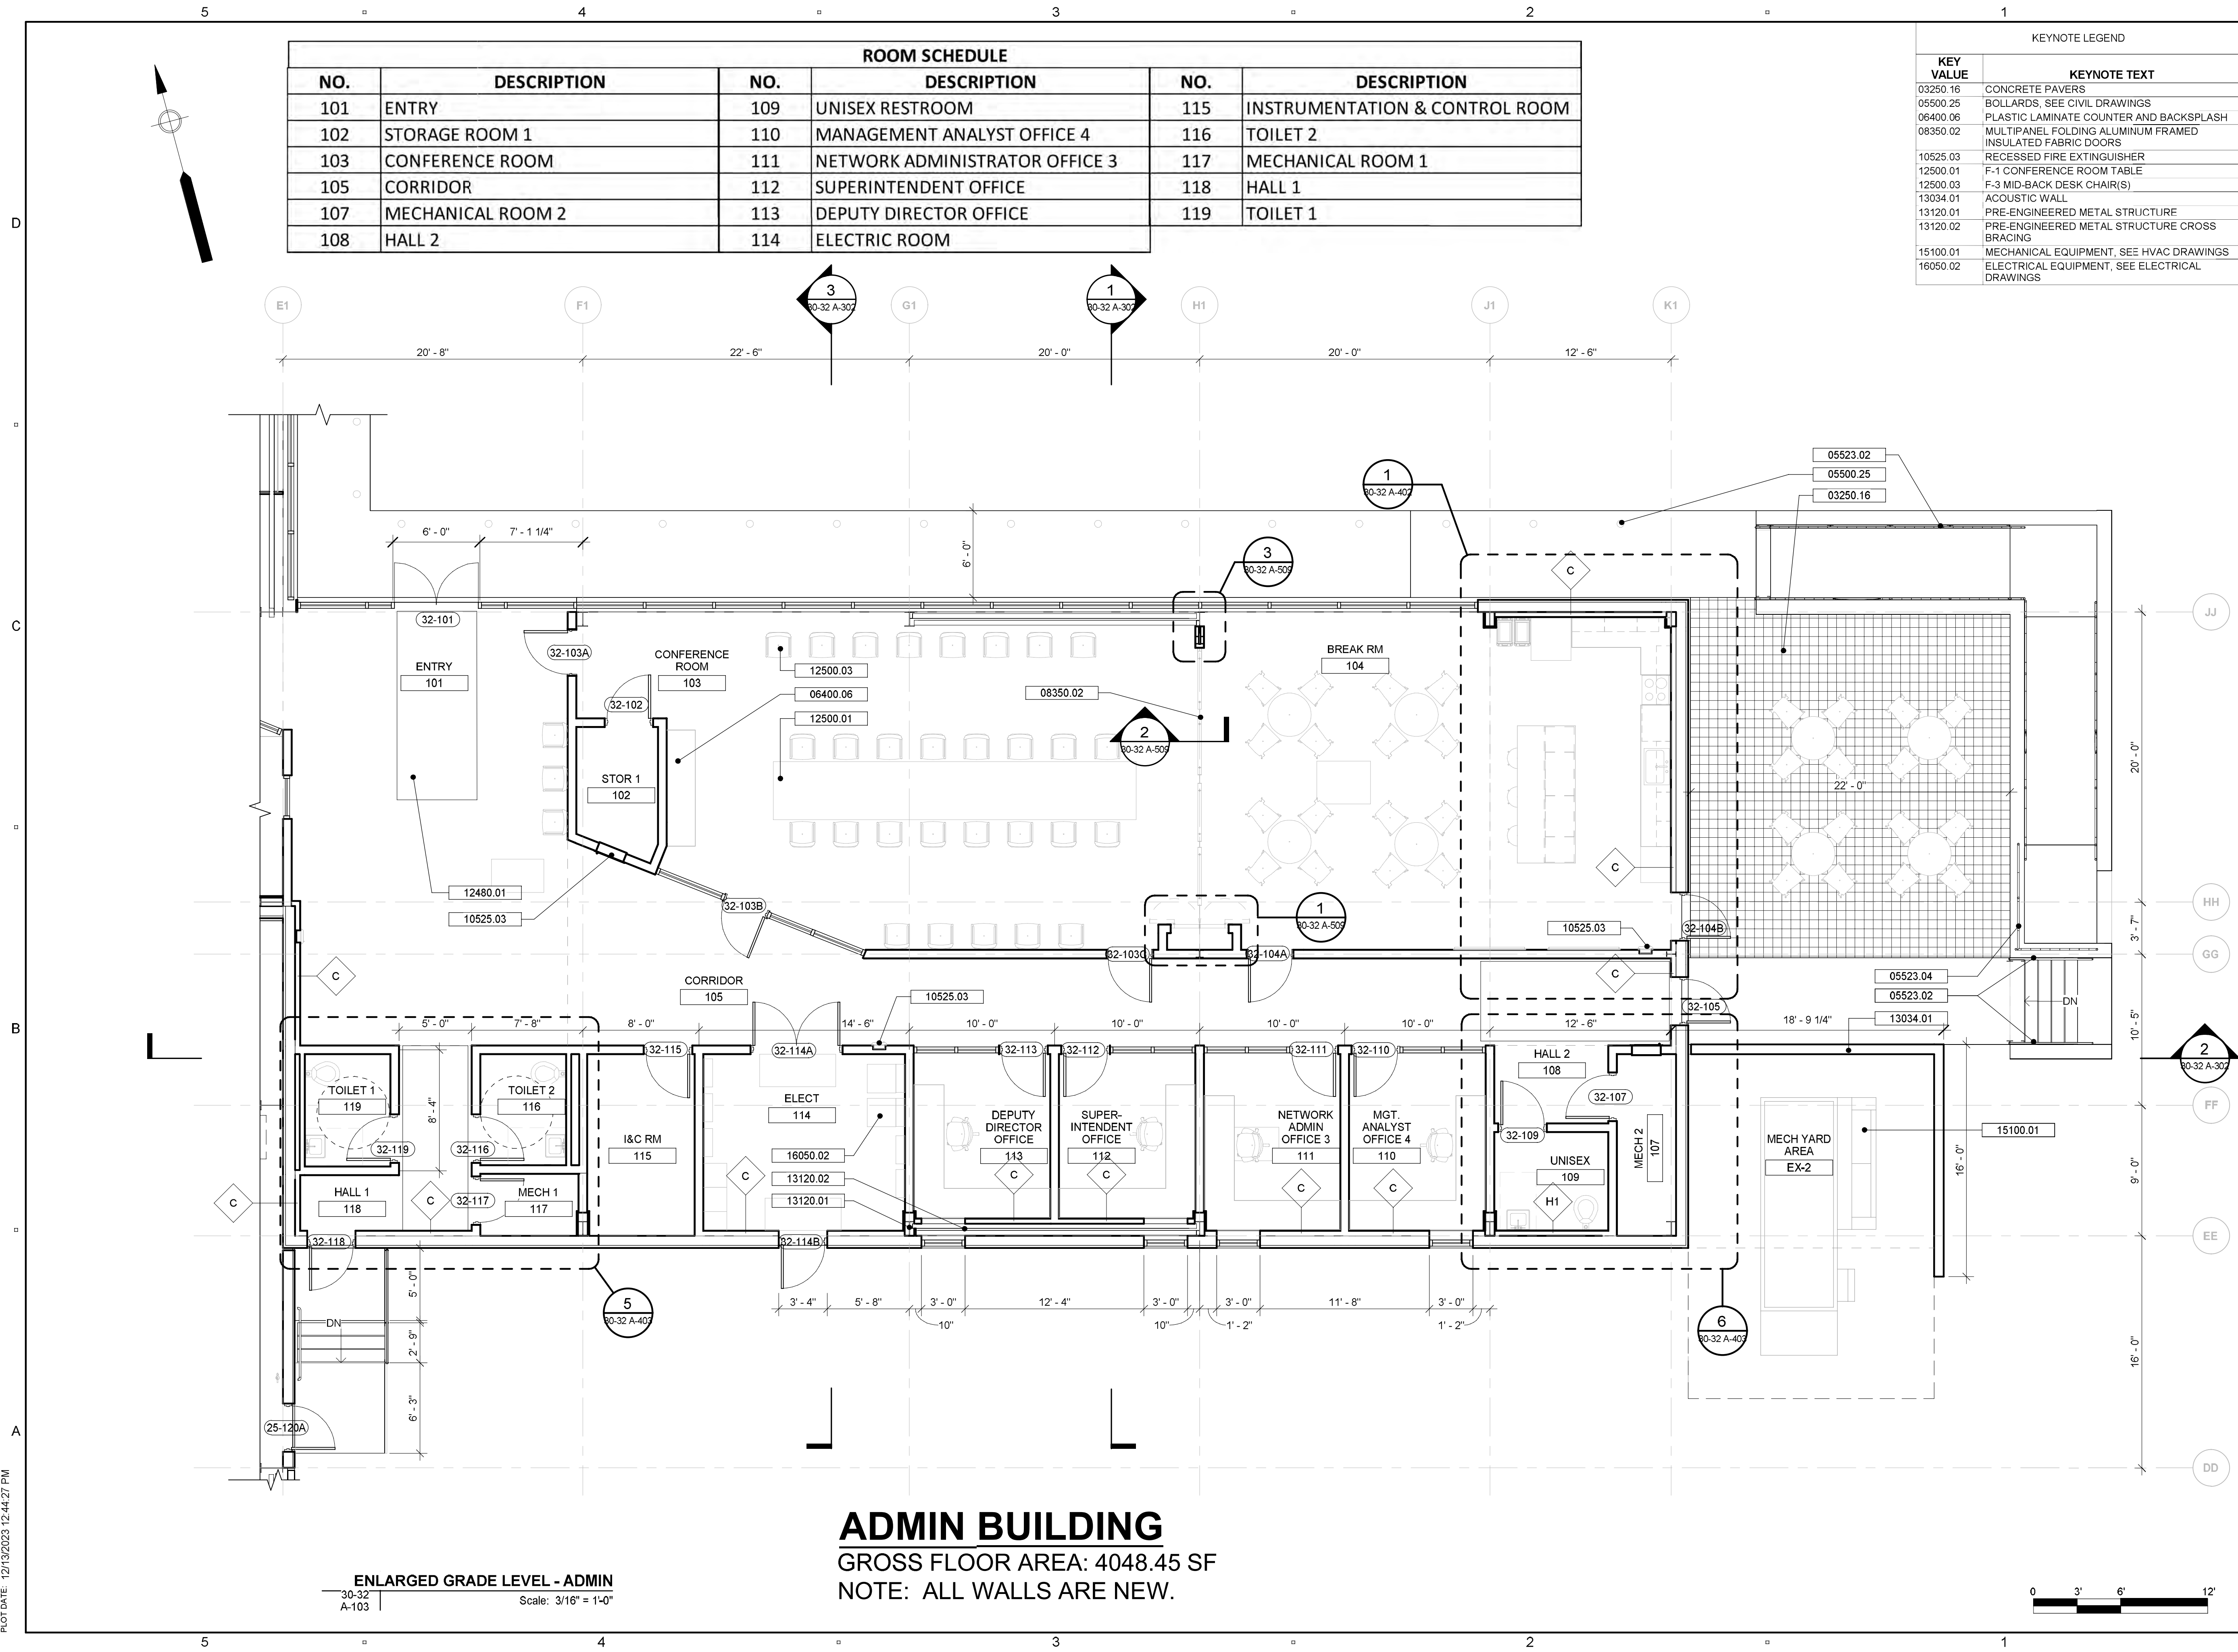

ADMIN BUILDING

GROSS FLOOR AREA: 4048.45 SF

NOTE: ALL WALLS ARE NEW.

ENLARGED GRADE LEVEL - ADMIN



PATH/FILENAME: AutodesK Docs:/60667213-GHWTP FIP/30-32-A-Admin & Operations Buildings.rvt
LAST UPDATE: 12/13/2023 12:44:27 PM
PLOT DATE: 12/13/2023 12:44:27 PM

60667213

5 4 3 2 1

D

C

B

A

5 4 3 2 1

60667213

60667213-GHWTP_FIP/85-A-Maintenance Building.rvt

LAST UPDATE: 12/13/2023 11:27:41 AM

PLOT DATE: 12/13/2023 11:27:41 AM

ROOM SCHEDULE			
NO.	DESCRIPTION	NO.	DESCRIPTION
101	MECHANICAL ROOM	107	PAINT STORAGE ROOM
102	ELECTRICAL ROOM	108	BEAD BLASTING ROOM
103	SAFETY DEVICES STORAGE ROOM	109	WELDING ROOM
104	UNISEX RESTROOM	110	MECHANICAL COMPONENT STORAGE ROOM
105	CORRIDOR	111	OIL AND LUBE ROOM
106	WORKSHOP/DRIVE-IN AREA	112	STORAGE

KEY VALUE	KEYNOTE TEXT
03300.03	CONCRETE PLATFORM, SEE STRUCTURAL DWGS
03300.04	CONCRETE ENTRANCE PAD, SEE STRUCTURAL DWGS
05500.25	BOLLARDS, SEE CIVIL DRAWINGS
10525.01	FIRE EXTINGUISHER
10525.03	RECESSED FIRE EXTINGUISHER
10525.06	FIRST AID BOX
10801.11	SHOWER CURTAIN ROD
10801.13	36" GRAB BAR
10801.18	SHOWER STALL
10801.20	ADA SINK
10999.04	PRECAST CONCRETE SPLASH BLOCK
15130.13	MOP SINK
16050.02	ELECTRICAL EQUIPMENT, SEE ELECTRICAL DRAWINGS

AECOM **W.M. LYLES CO.**

a joint venture

PROJECT

GRAHAM HILL WATER
TREATMENT PLANT - FACILITY
IMPROVEMENTS PROJECT

715 Graham Hill Rd,
Santa Cruz, CA 95060
APN 060-141-05

OWNER

**CITY OF SANTA CRUZ
WATER DEPARTMENT**

212 Locust St Ste A
Santa Cruz, CA 95060
PHONE: (831) 420-5200



ENGINEER

AECOM TECHNICAL SERVICES, INC.
250 APOLLO DRIVE
CHELMSFORD, MA 01824
PHONE: (978) 905-2100
www.aecom.com


AECOM TECHNICAL SERVICES, INC.
2020 L STREET
SACRAMENTO, CA 95811
PHONE: (916) 414-5800
www.aecom.com

CONSULTANTS

KENNEDY JENKS (Design assistance)
275 Battery Street, Suit 550
San Francisco, CA 94111
www.kennedyjenks.com

BOWMAN & WILLIAMS (Surveyor)
3949 Research Park Court, Suit 100
Soquel, CA 95073
www.bowmanandwilliams.com

REGISTRATION

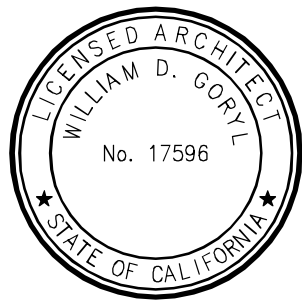

ISSUE/REVISION

NO.	DATE	DESCRIPTION

PROJECT NUMBER

60667213

Designed By:	M. PICONE
Drawn By:	M. PICONE
Dept Check:	W. GORYL
Approved by:	G. PERIGAUULT
Date:	DECEMBER 2023
Scale:	1/4" = 1'-0"

DISCIPLINE


ARCHITECTURAL
SHEET TITLE

**MAINTENANCE
BUILDING - FLOOR PLAN**

SHEET NUMBER

85-A-101

PAGE 7 OF 27

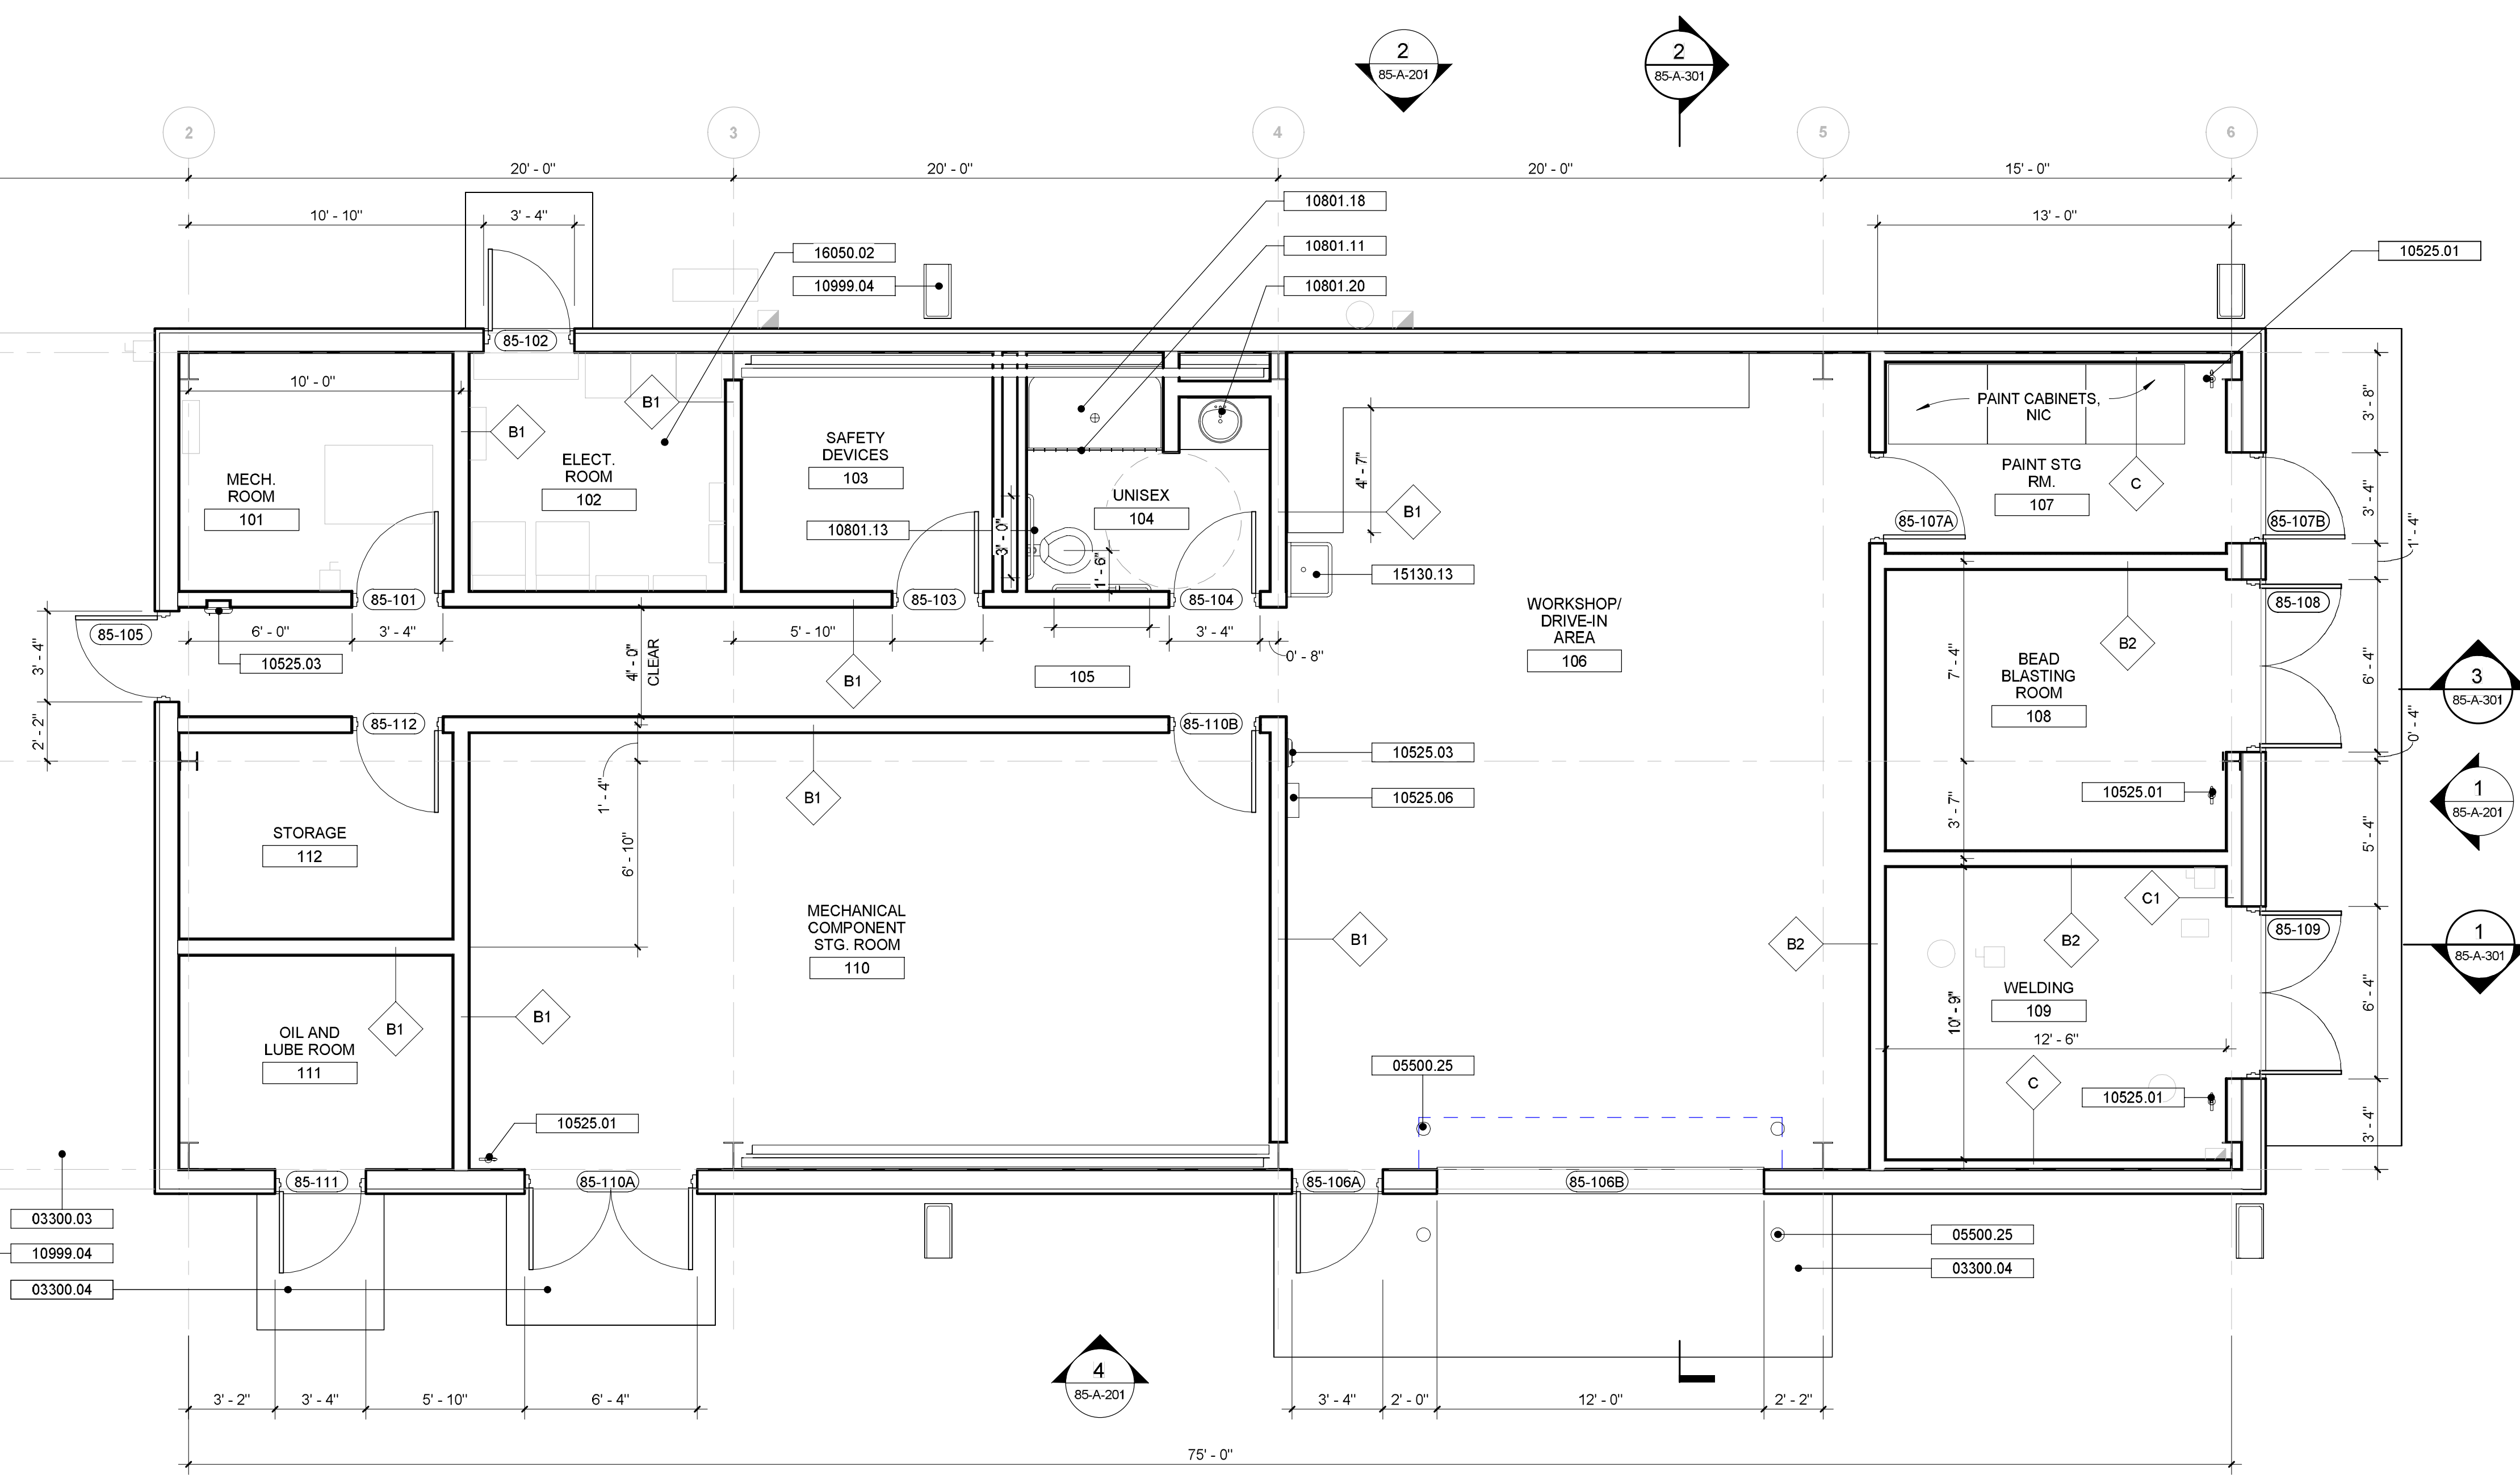


1 MAINTENANCE BUILDING - GRADE LEVEL PLAN
85-A-101 Scale: 1/4" = 1'-0"

MAINTENANCE BUILDING
TOTAL GROSS FLOOR AREA: 2,270 SF



PATH\\FLEN\\MIE: Autodes\\Dcs\\60667213-GH\\WTP_FIP\\30-32-A-Admin & Operations Buildings.rvt
LAST UPDATE: 12/13/2023 12:45:23 PM
PLOT DATE: 12/13/2023 12:45:23 PM

60667213

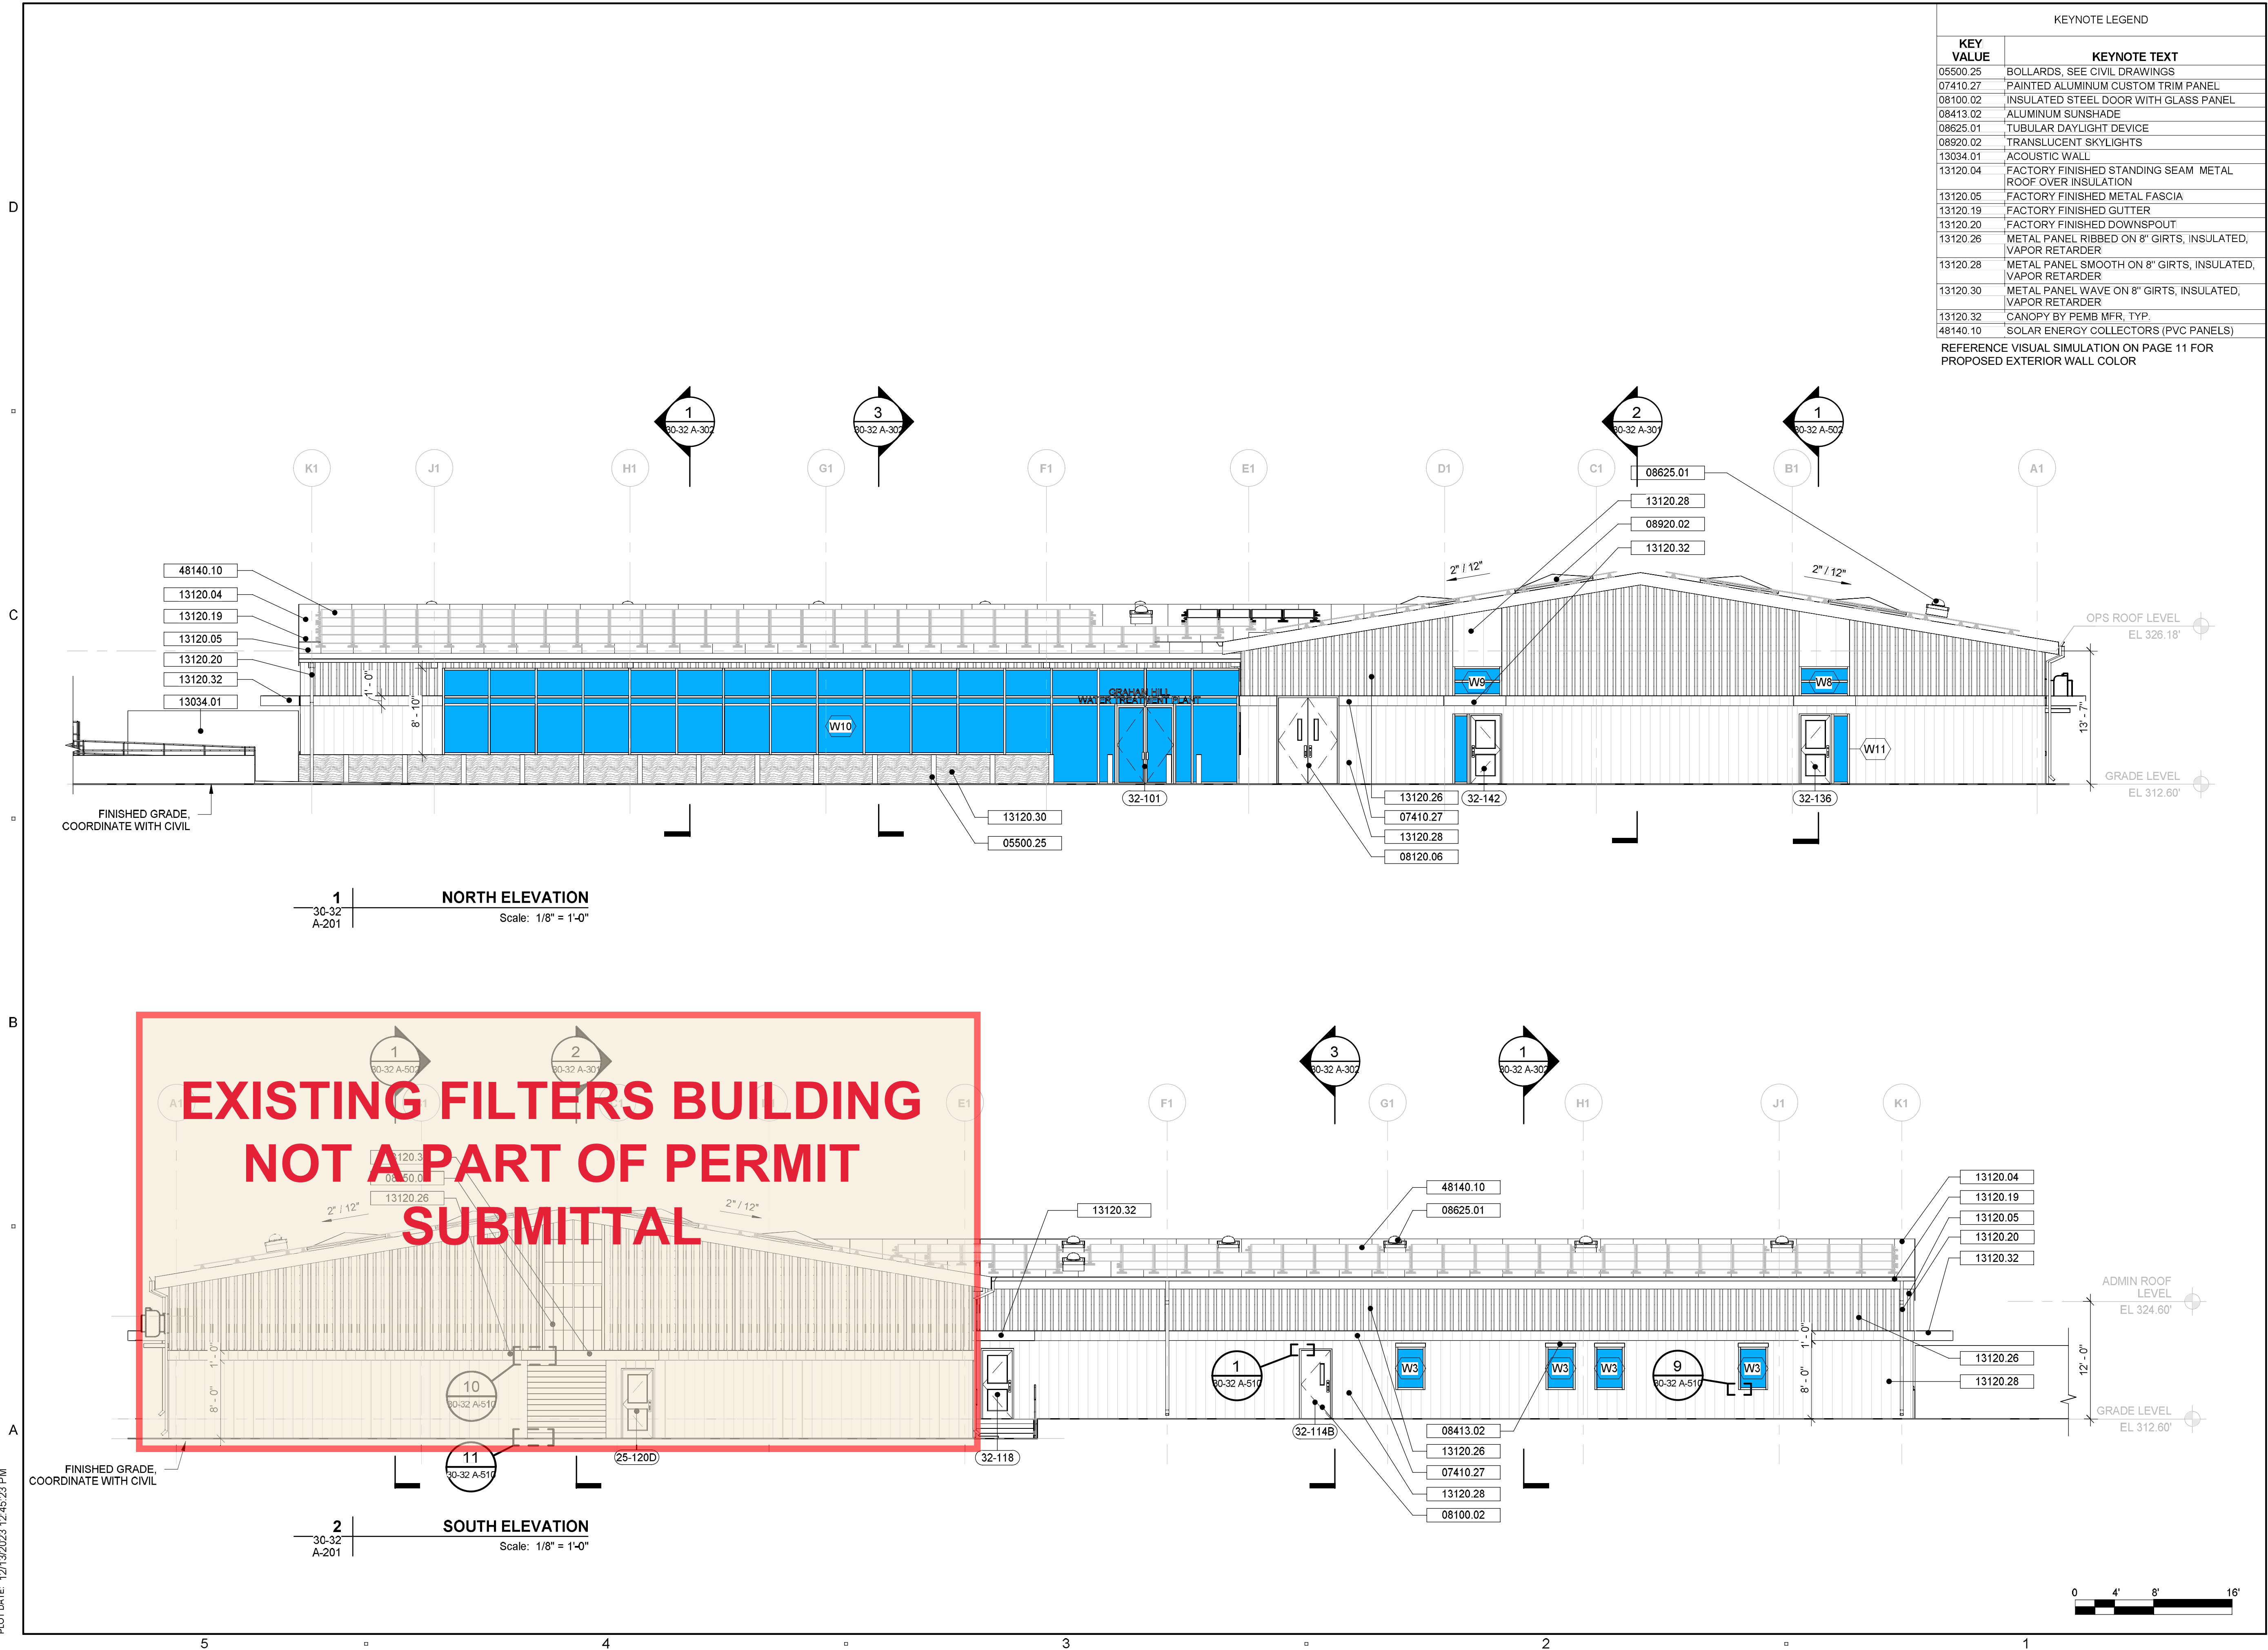

KEYNOTE LEGEND	
KEY VALUE	KEYNOTE TEXT
05500.25	BOLLARDS, SEE CIVIL DRAWINGS
07410.27	PAINTED ALUMINUM CUSTOM TRIM PANEL
08100.02	INSULATED STEEL DOOR WITH GLASS PANEL
08413.02	ALUMINUM SUNSHADE
08625.01	TUBULAR DAYLIGHT DEVICE
08920.02	TRANSLUCENT SKYLIGHTS
13034.01	ACOUSTIC WALL
13120.04	FACTORY FINISHED STANDING SEAM METAL ROOF OVER INSULATION
13120.05	FACTORY FINISHED METAL FASCIA
13120.19	FACTORY FINISHED GUTTER
13120.20	FACTORY FINISHED DOWNSPOUT
13120.26	METAL PANEL RIBBED ON 8" GIRTS, INSULATED, VAPOR RETARDER
13120.28	METAL PANEL SMOOTH ON 8" GIRTS, INSULATED, VAPOR RETARDER
13120.30	METAL PANEL WAVE ON 8" GIRTS, INSULATED, VAPOR RETARDER
13120.32	CANOPY BY PEMB MFR, TYP.
48140.10	SOLAR ENERGY COLLECTORS (PVC PANELS)
REFERENCE VISUAL SIMULATION ON PAGE 11 FOR PROPOSED EXTERIOR WALL COLOR	

AECOM **W.M. LYLES CO.**
a joint venture

PROJECT

**GRAHAM HILL WATER
TREATMENT PLANT - FACILITY
IMPROVEMENTS PROJECT**

715 Graham Hill Rd,
Santa Cruz, CA 95060
APN 060-141-05

OWNER

**CITY OF SANTA CRUZ
WATER DEPARTMENT**

212 Locust St Ste A
Santa Cruz, CA 95060
PHONE: (831) 420-5200



ENGINEER

AECOM TECHNICAL SERVICES, INC.
250 APOLLO DRIVE
CHELMSFORD, MA 01824
PHONE: (978) 905-2100
www.aecom.com

AECOM TECHNICAL SERVICES, INC.
2020 L STREET
SACRAMENTO, CA 95811
PHONE: (916) 414-5800
www.aecom.com

CONSULTANTS

KENNEDY JENKS (Design assistance)
275 Battery Street, Suite 550
San Francisco, CA 94111
www.kennedyjenks.com

BOWMAN & WILLIAMS (Surveyor)
3949 Research Park Court, Suite 100
Soquel, CA 95073
www.bowmanandwilliams.com

REGISTRATION



ISSUE/REVISION

IR	DATE	DESCRIPTION

PROJECT NUMBER

60667213
Designed By: W. GORYL
Drawn By: M. PICONE
Dept Check: G. OTTERSON
Approved by: G. PERIGAULT
Date: DECEMBER 2023
Scale: 1/8" = 1'-0"


DISCIPLINE

**ARCHITECTURAL
SHEET TITLE**


**ADMIN & OPS BUILDING -
ELEVATIONS I**

SHEET NUMBER


30-32 A-201 PAGE 8 OF 27

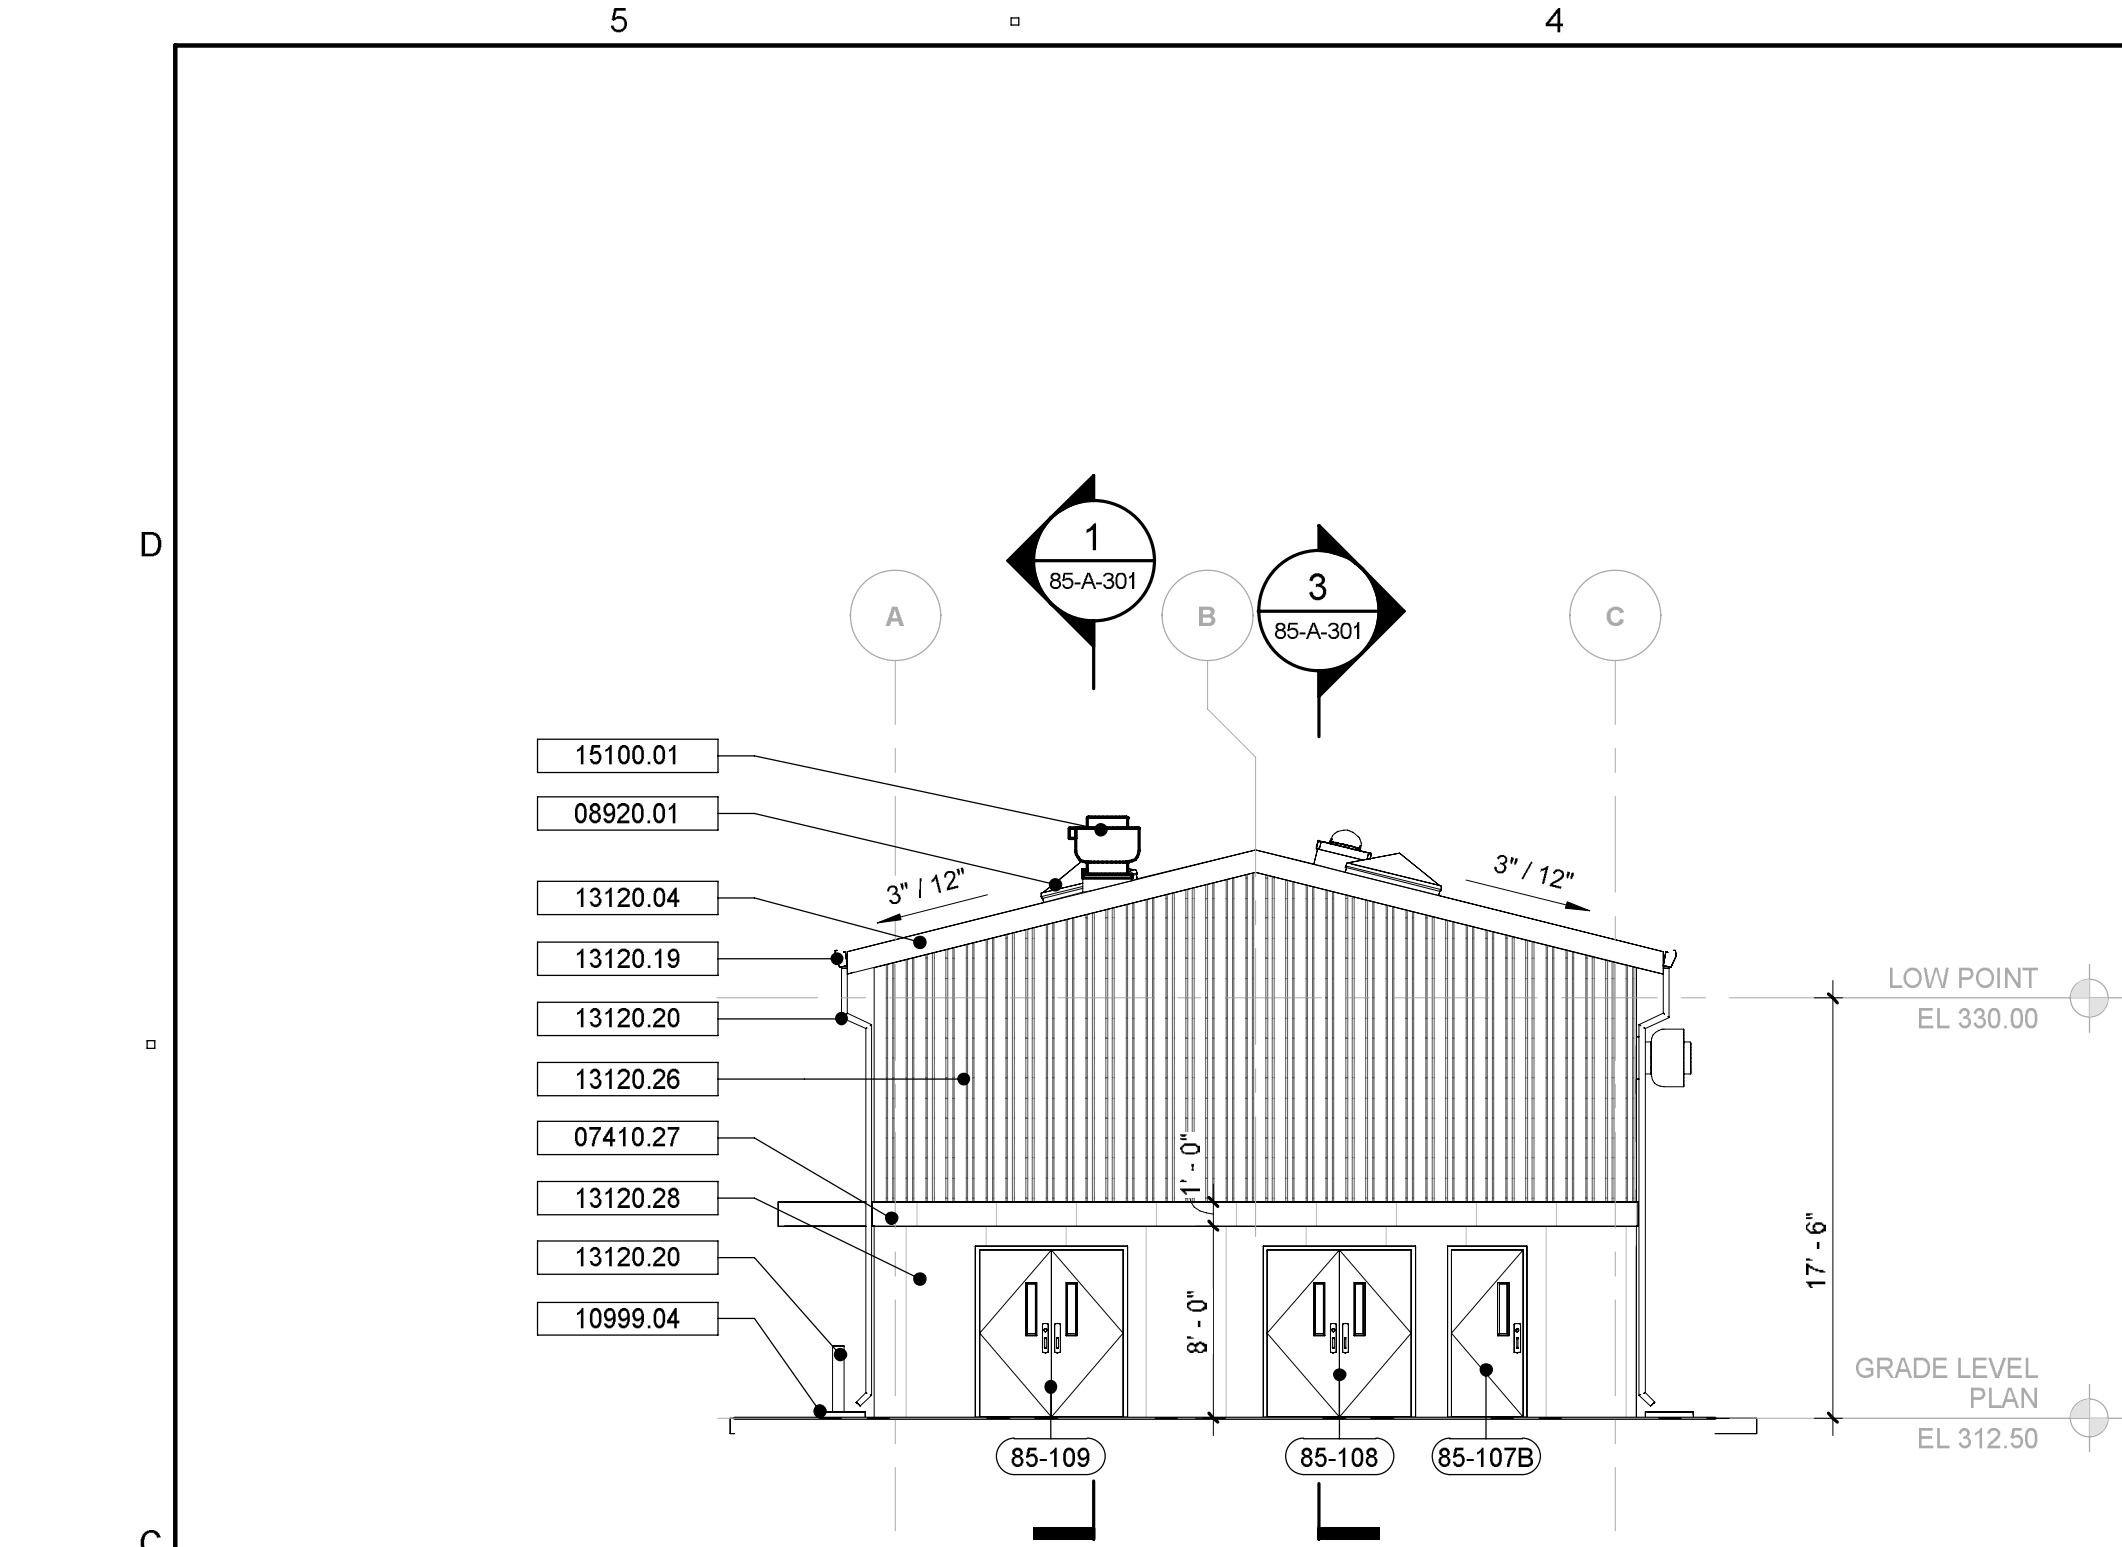


1 | MAINTENANCE BUILDING - NORTH ELEVATION
85-A-201 | Scale: 1/8" = 1'-0"

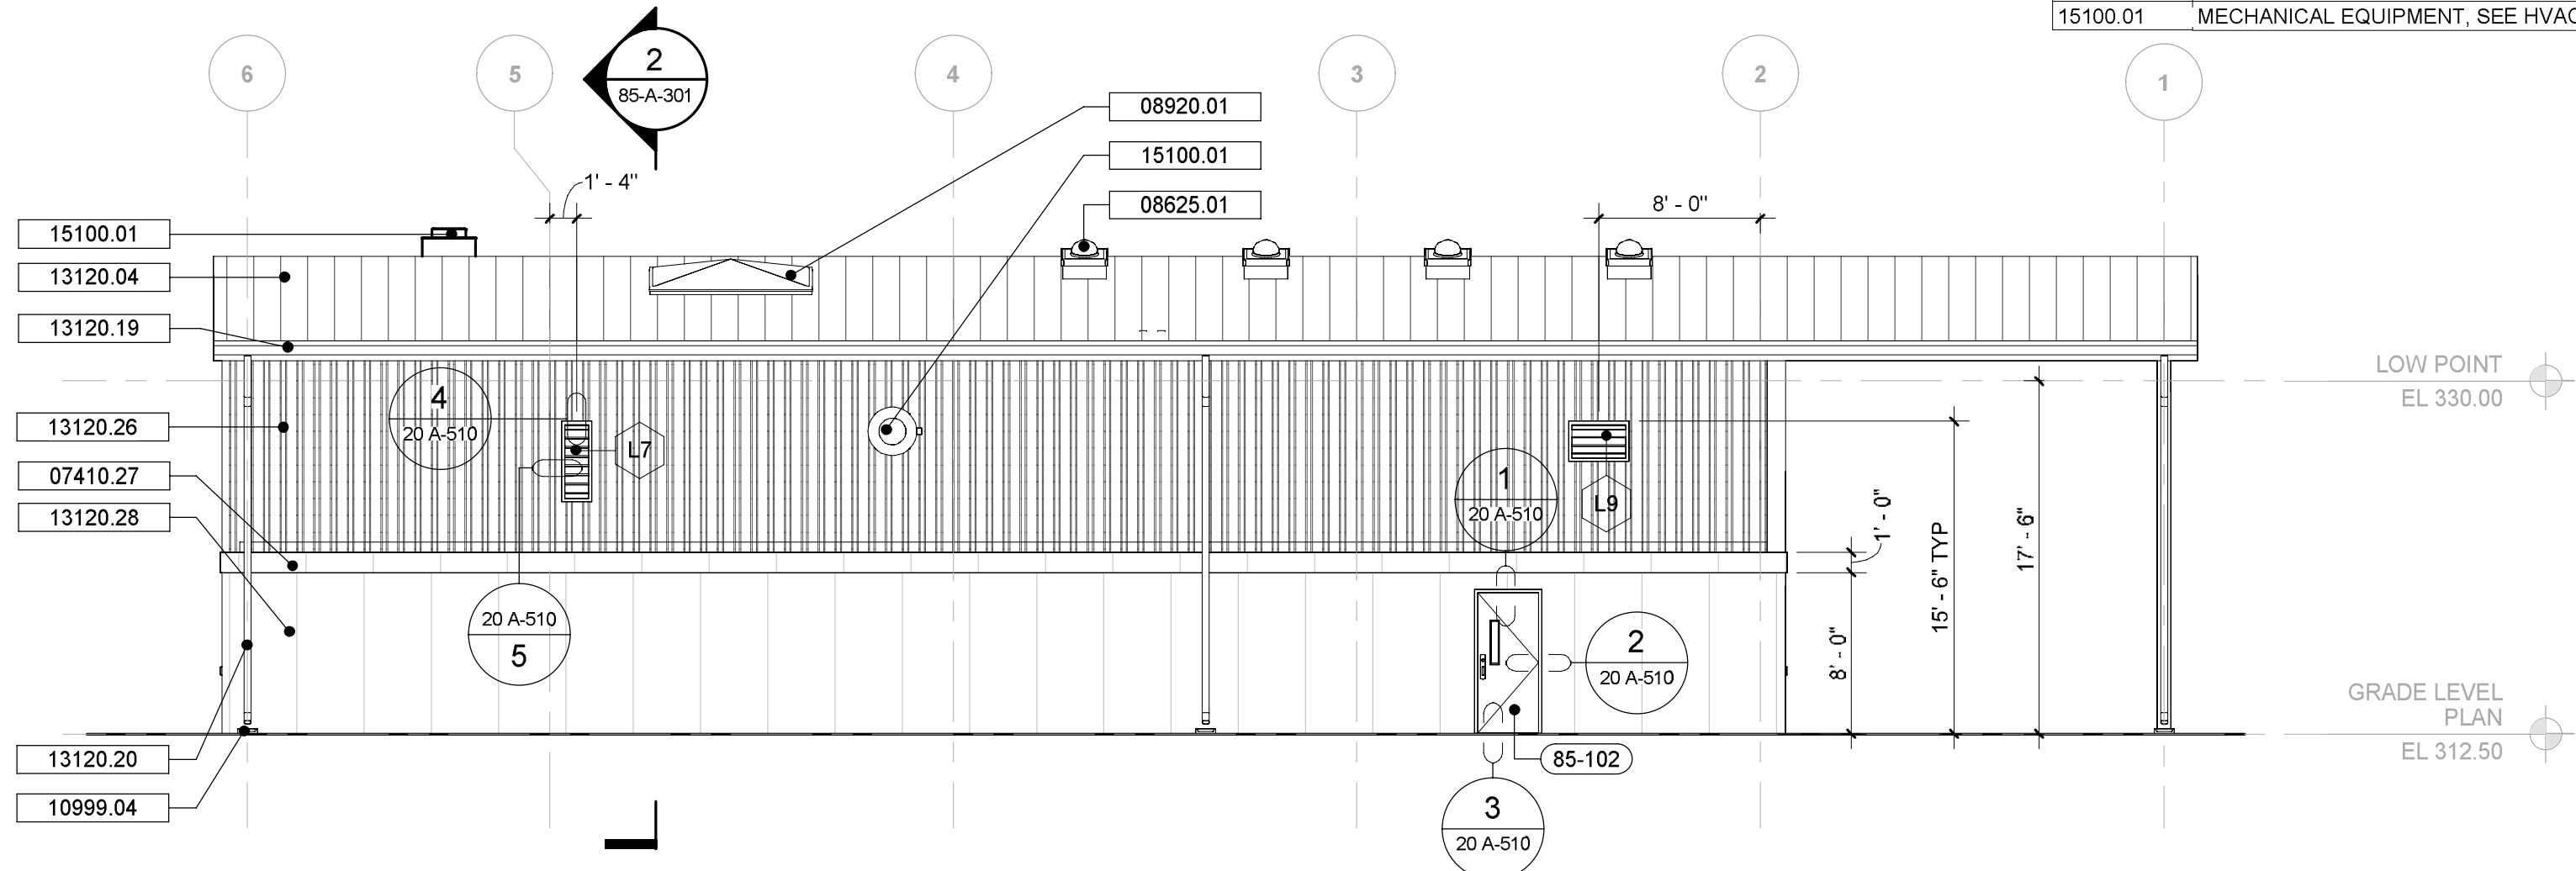

2 | MAINTENANCE BUILDING - WEST ELEVATION
85-A-201 | Scale: 1/8" = 1'-0"

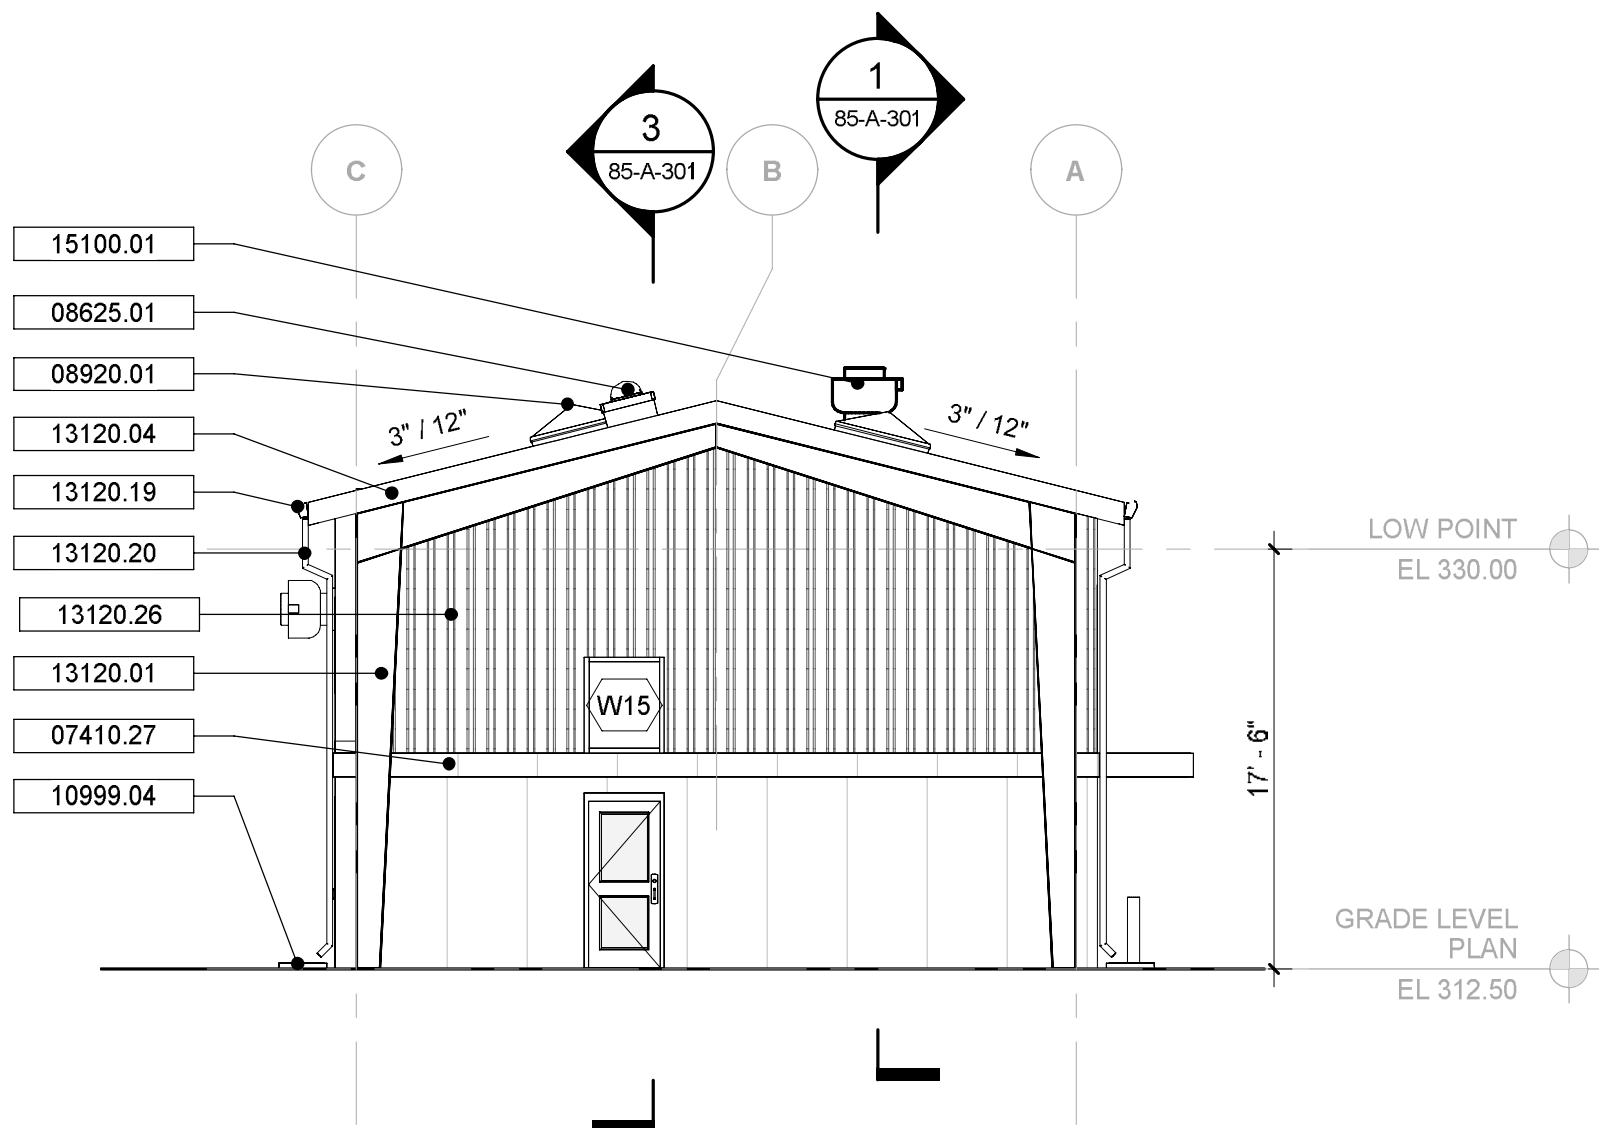

3 | MAINTENANCE BUILDING - SOUTH ELEVATION
85-A-201 | Scale: 1/8" = 1'-0"

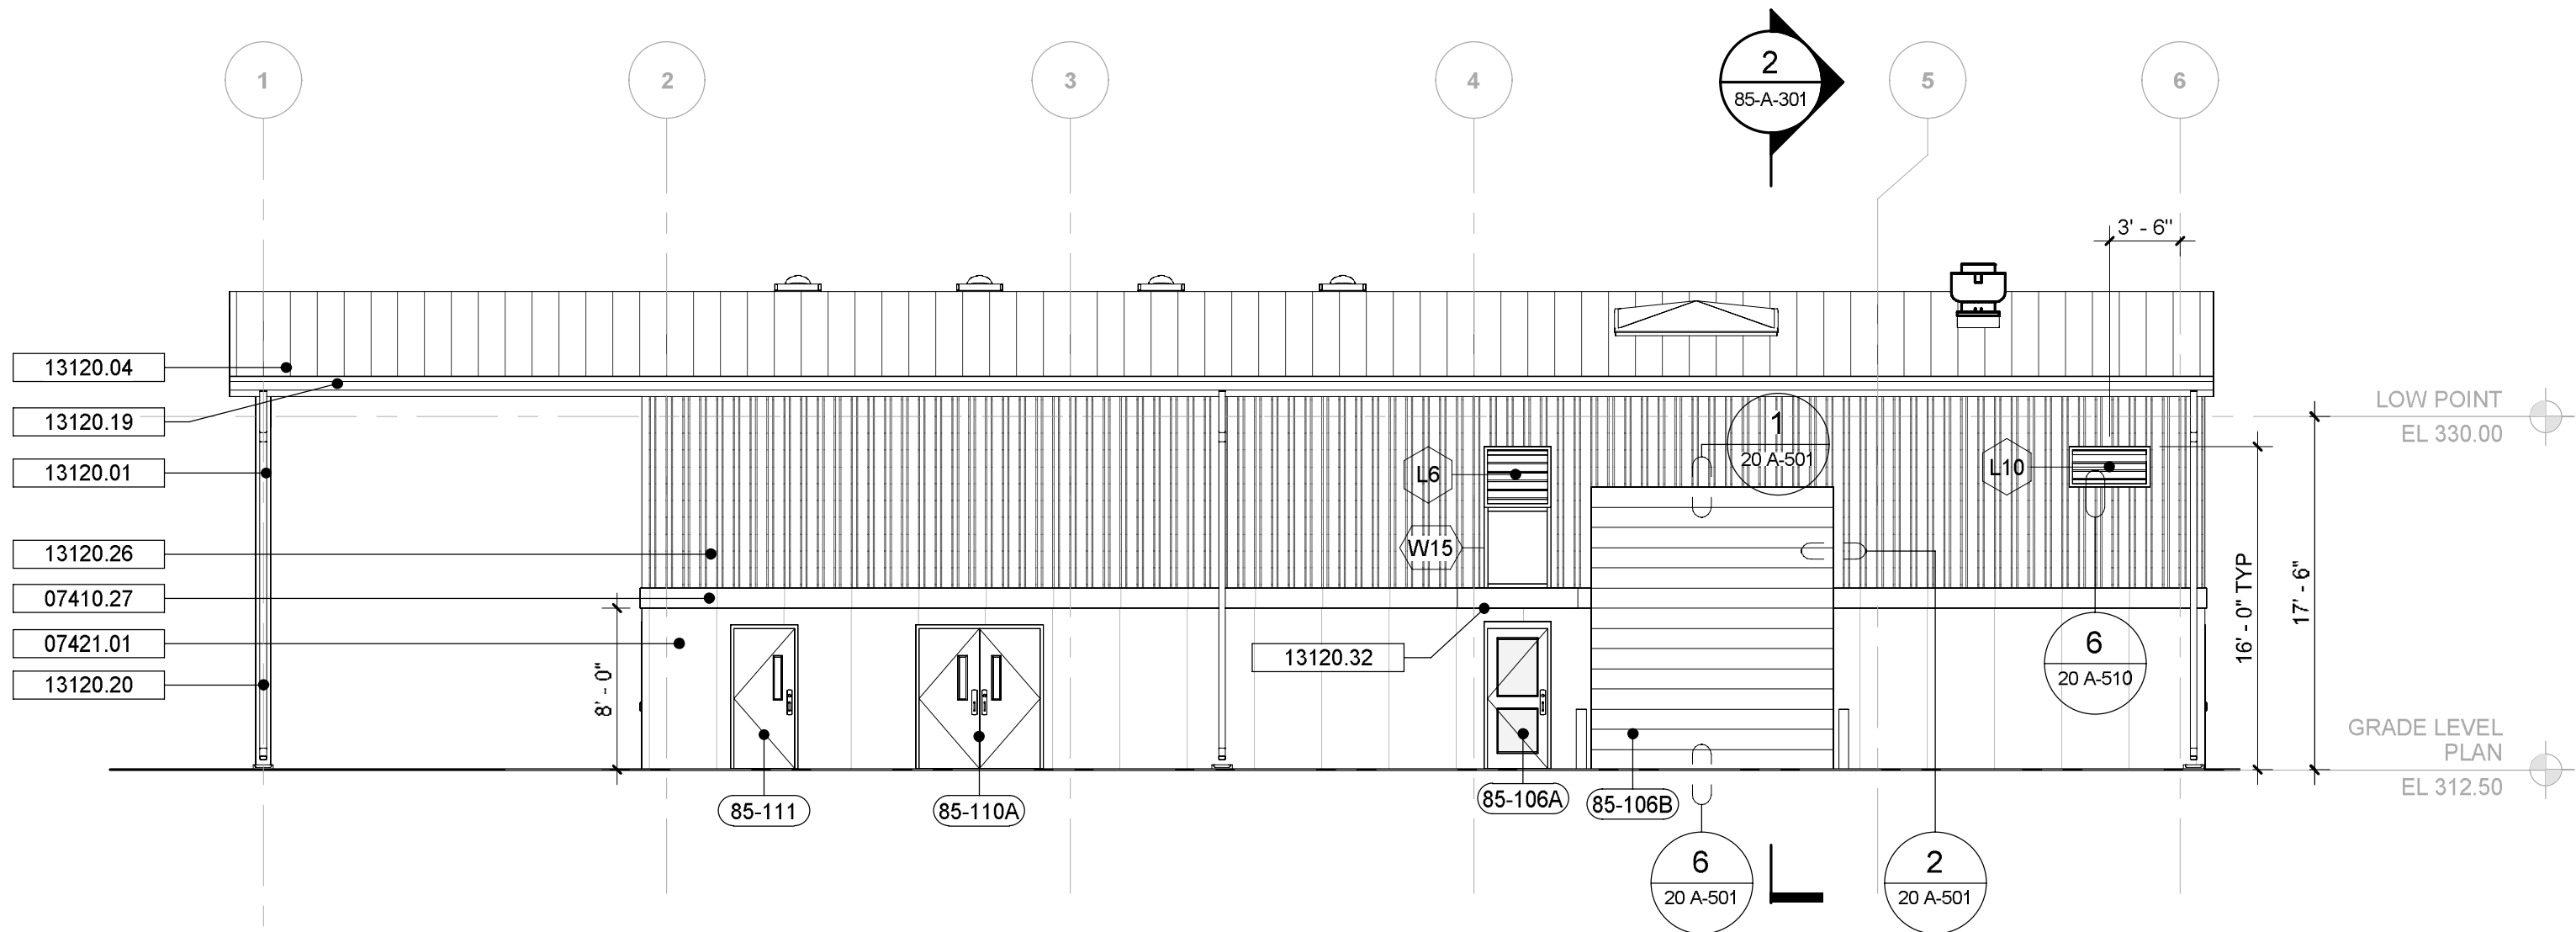

4 | MAINTENANCE BUILDING - EAST ELEVATION
85-A-201 | Scale: 1/8" = 1'-0"

MAINTENANCE BUILDING WILL HAVE SAME COLOR AS
ADMIN & OPS BUILDING - REFERENCE VISUAL SIMULATION
ON PAGE FOR PROPOSED EXTERIOR WALL COLOR

KEY VALUE	KEYNOTE TEXT
07410.27	PAINTED ALUMINUM CUSTOM TRIM PANEL
08625.01	TUBULAR DAYLIGHT DEVICE
08920.01	TRANSLUCENT REMOVABLE SKYLIGHTS
10999.04	PRECAST CONCRETE SPLASH BLOCK
13120.01	PRE-ENGINEERED METAL STRUCTURE
13120.04	FACTORY FINISHED STANDING SEAM METAL ROOF OVER INSULATION
13120.19	FACTORY FINISHED GUTTER
13120.20	FACTORY FINISHED DOWNSPOUT
13120.26	METAL PANEL RIBBED ON 8" GIRTS, INSULATED, VAPOR RETARDER
13120.28	METAL PANEL SMOOTH ON 8" GIRTS, INSULATED, VAPOR RETARDER
13120.32	CANOPY BY PEMB MFR, TYP.
15100.01	MECHANICAL EQUIPMENT, SEE HVAC DRAWINGS

AECOM **W.M. LYLES CO.**
a joint venture

PROJECT

GRAHAM HILL WATER
TREATMENT PLANT - FACILITY
IMPROVEMENTS PROJECT

715 Graham Hill Rd,
Santa Cruz, CA 95060
APN 060-141-05

OWNER

**CITY OF SANTA CRUZ
WATER DEPARTMENT**

212 Locust St Ste A
Santa Cruz, CA 95060
PHONE: (831) 420-5200



ENGINEER

AECOM TECHNICAL SERVICES, INC.
250 APOLLO DRIVE
CHELMSFORD, MA 01824
PHONE: (978) 905-2100
www.aecom.com

AECOM TECHNICAL SERVICES, INC.
2020 L STREET
SACRAMENTO, CA 95811
PHONE: (916) 414-5800
www.aecom.com

CONSULTANTS

KENNEDY JENKS (Design assistance)
275 Battery Street, Suite 550
San Francisco, CA 94111
www.kennedyjenks.com

BOWMAN & WILLIAMS (Surveyor)
3949 Research Park Court, Suite 100
Soquel, CA 95073
www.bowmanandwilliams.com

REGISTRATION



ISSUE/REVISION

IR	DATE	DESCRIPTION

PROJECT NUMBER

60667213

Designed By: **M. PICONE**

Drawn By: **M. PICONE**

Dept Check: **W. GORYL**

Approved by: **G. PERIGAULT**

Date: **DECEMBER 2023**

Scale: **1/8" = 1'-0"**

DISCIPLINE

ARCHITECTURAL

SHEET TITLE

**MAINTENANCE
BUILDING - ELEVATIONS**

SHEET NUMBER

85-A-201

PAGE 10 OF 27



VISUAL SIMULATION OF PROPOSED PROJECT AT ENTRY GATE SHOWING 10 YEARS OF VEGETATIVE GROWTH AND ADMIN. BUILDING



VISUAL SIMULATION OF PROPOSED PROJECT FROM POGONIP OPEN SPACE LOOKOUT TRAIL



PROJECT

GRAHAM HILL WATER TREATMENT PLANT - FACILITY IMPROVEMENTS PROJECT

715 Graham Hill Rd.
Santa Cruz, CA 95060
APN 060-141-05

OWNER

CITY OF SANTA CRUZ WATER DEPARTMENT

212 Locust St Ste A
Santa Cruz, CA 95060
PHONE: (831) 420-5200



ENGINEER





AECOM TECHNICAL SERVICES, INC.
250 APOLLO DRIVE
CHELMSFORD, MA 01824
PHONE: (978) 905-2100
www.aecom.com

AECOM TECHNICAL SERVICES, INC.
2020 L STREET
SACRAMENTO, CA 95811
PHONE: (916) 414-5800
www.aecom.com

CONSULTANTS

KENNEDY JENKS (Design assistance)
275 Battery Street, Suite 550
San Francisco, CA 94111
www.kennedyjenks.com


BOWMAN & WILLIAMS (Surveyor)
3949 Research Park Court, Suite 100
Soquel, CA 95073
www.bowmanandwilliams.com

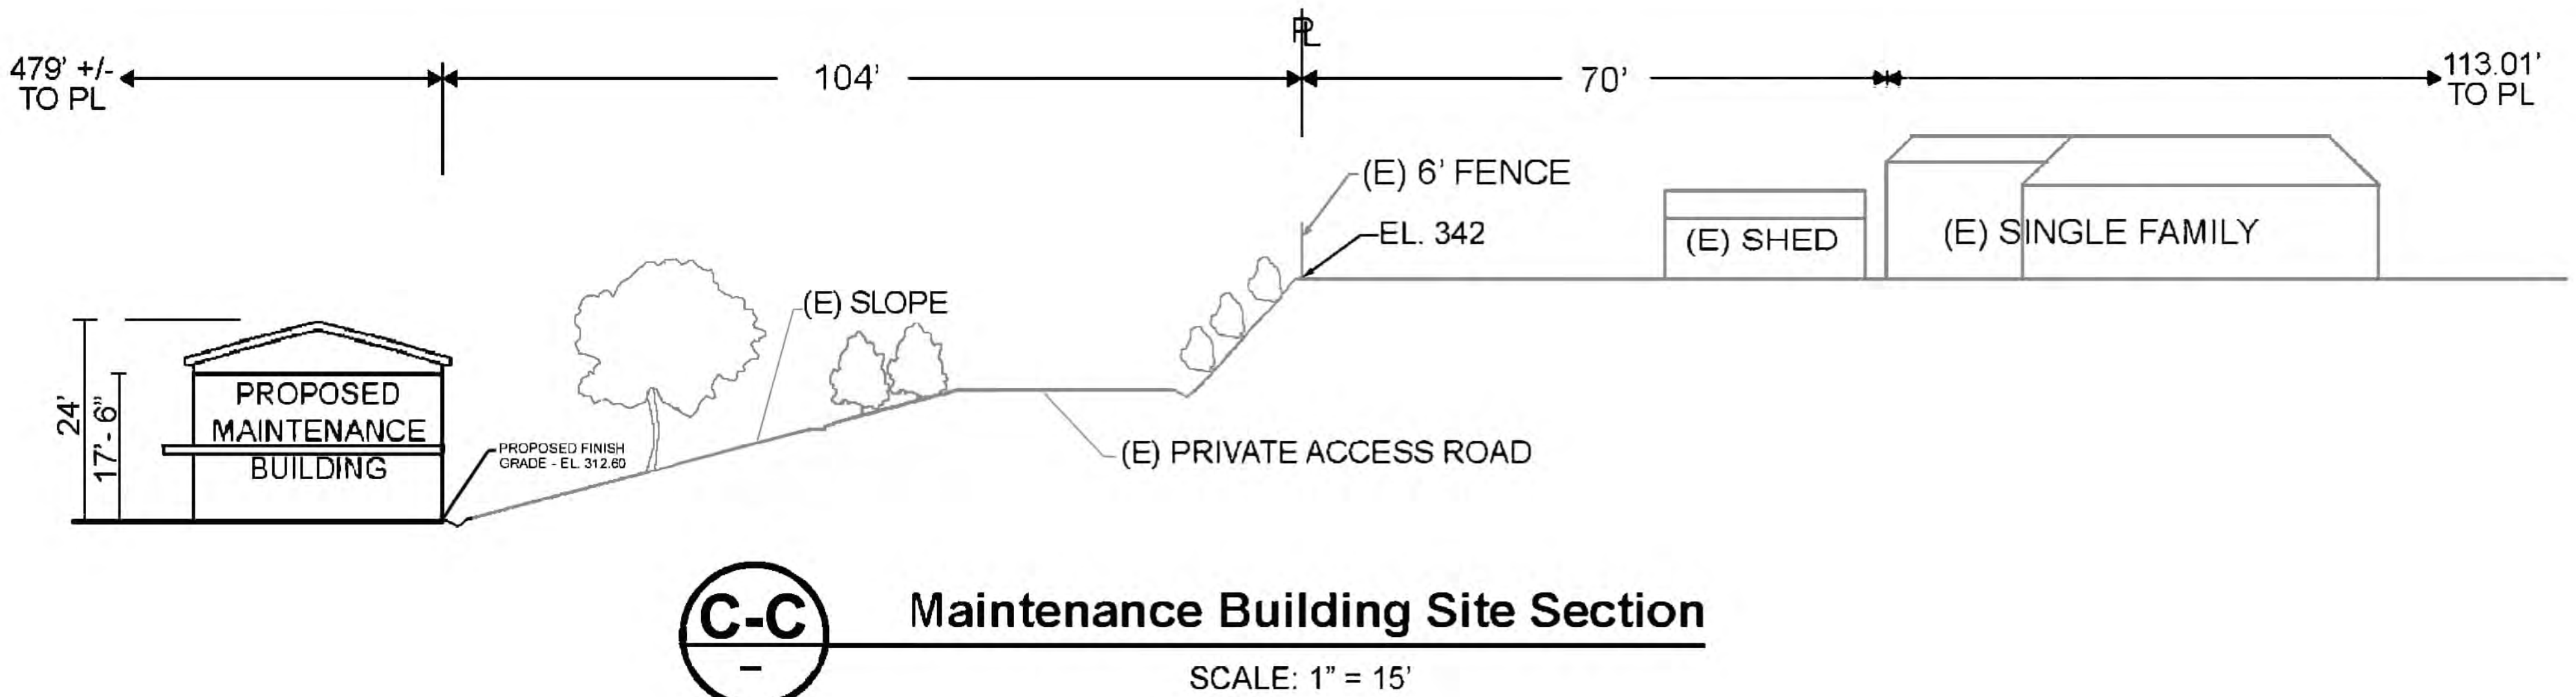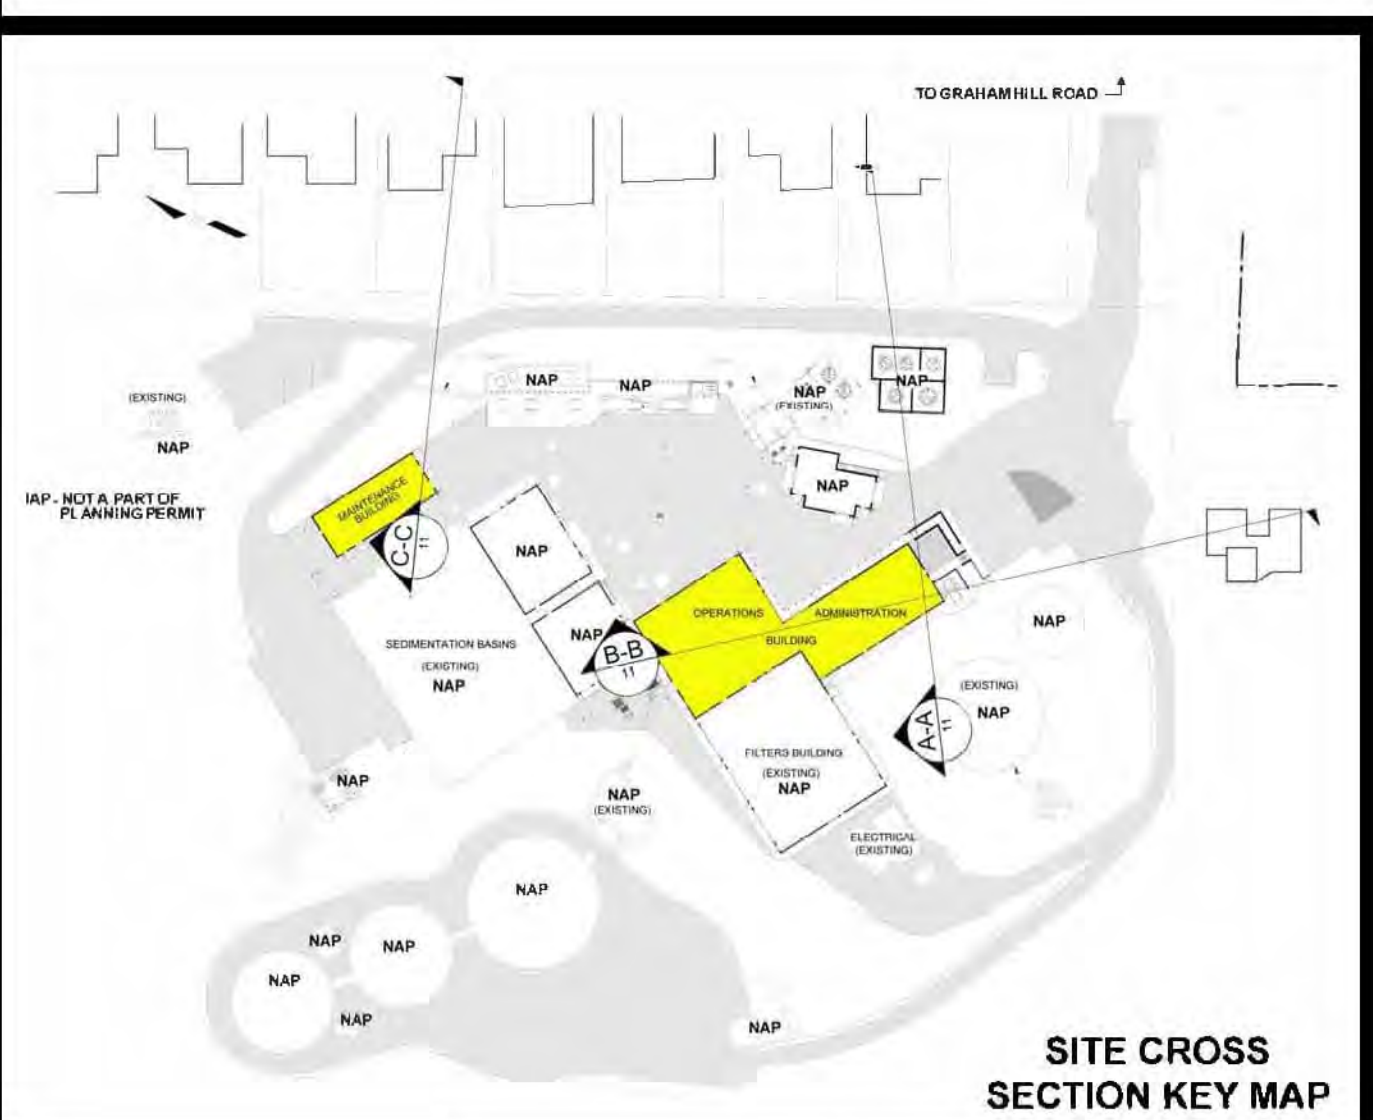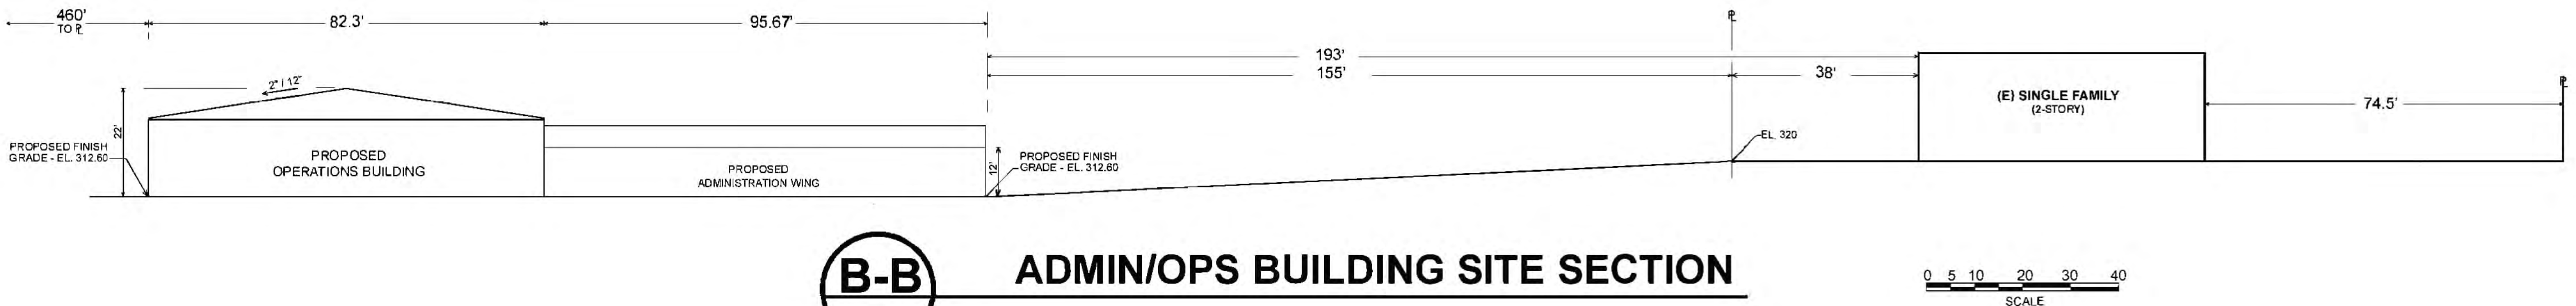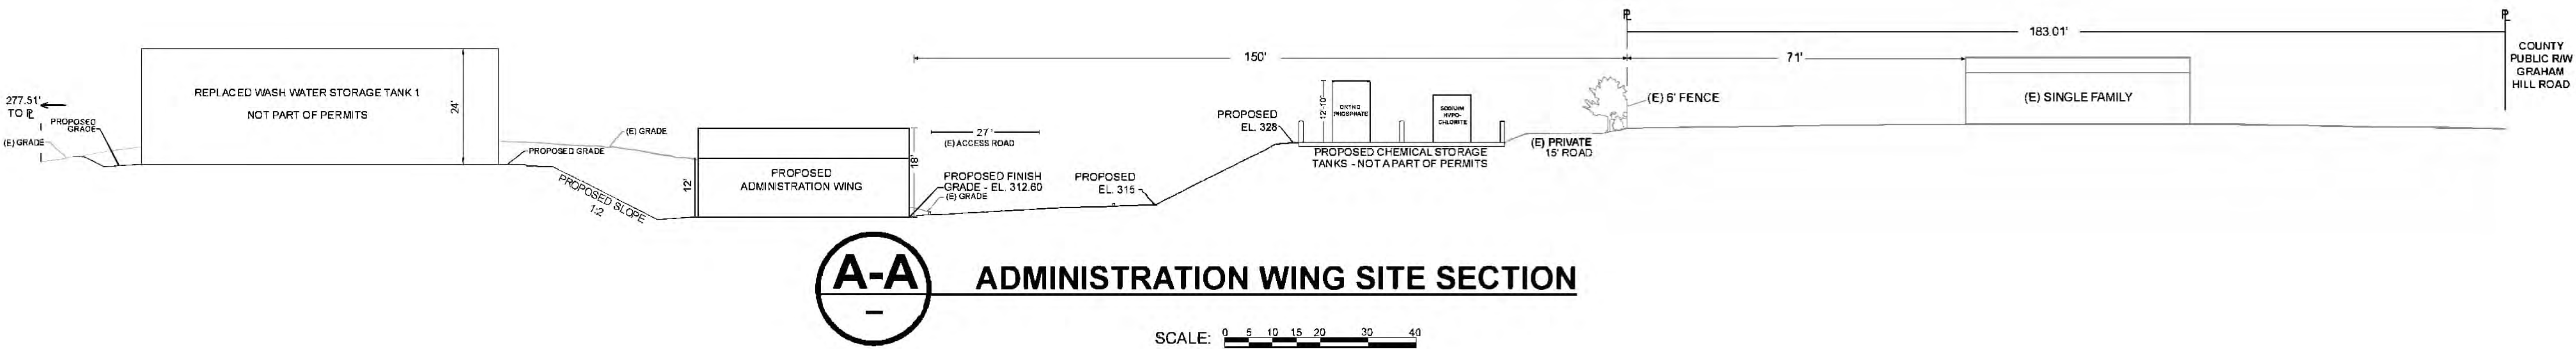

ISSUE/REVISION

I/R	DATE	DESCRIPTION
PROJECT NUMBER		
60667213		
Designed By:	W. GORYL	
Drawn By:		
Dept Check:		
Approved by:	G. PERIGAULT	
Date:		
Scale:		
PLANNING DEPT. PERMIT APPLICATION		

SHEET TITLE
ADMIN/OPS BUILDING & MAINTENANCE BUILDING
CONTEXT & BUILDING AND SITE SECTIONS
SHEET NUMBER

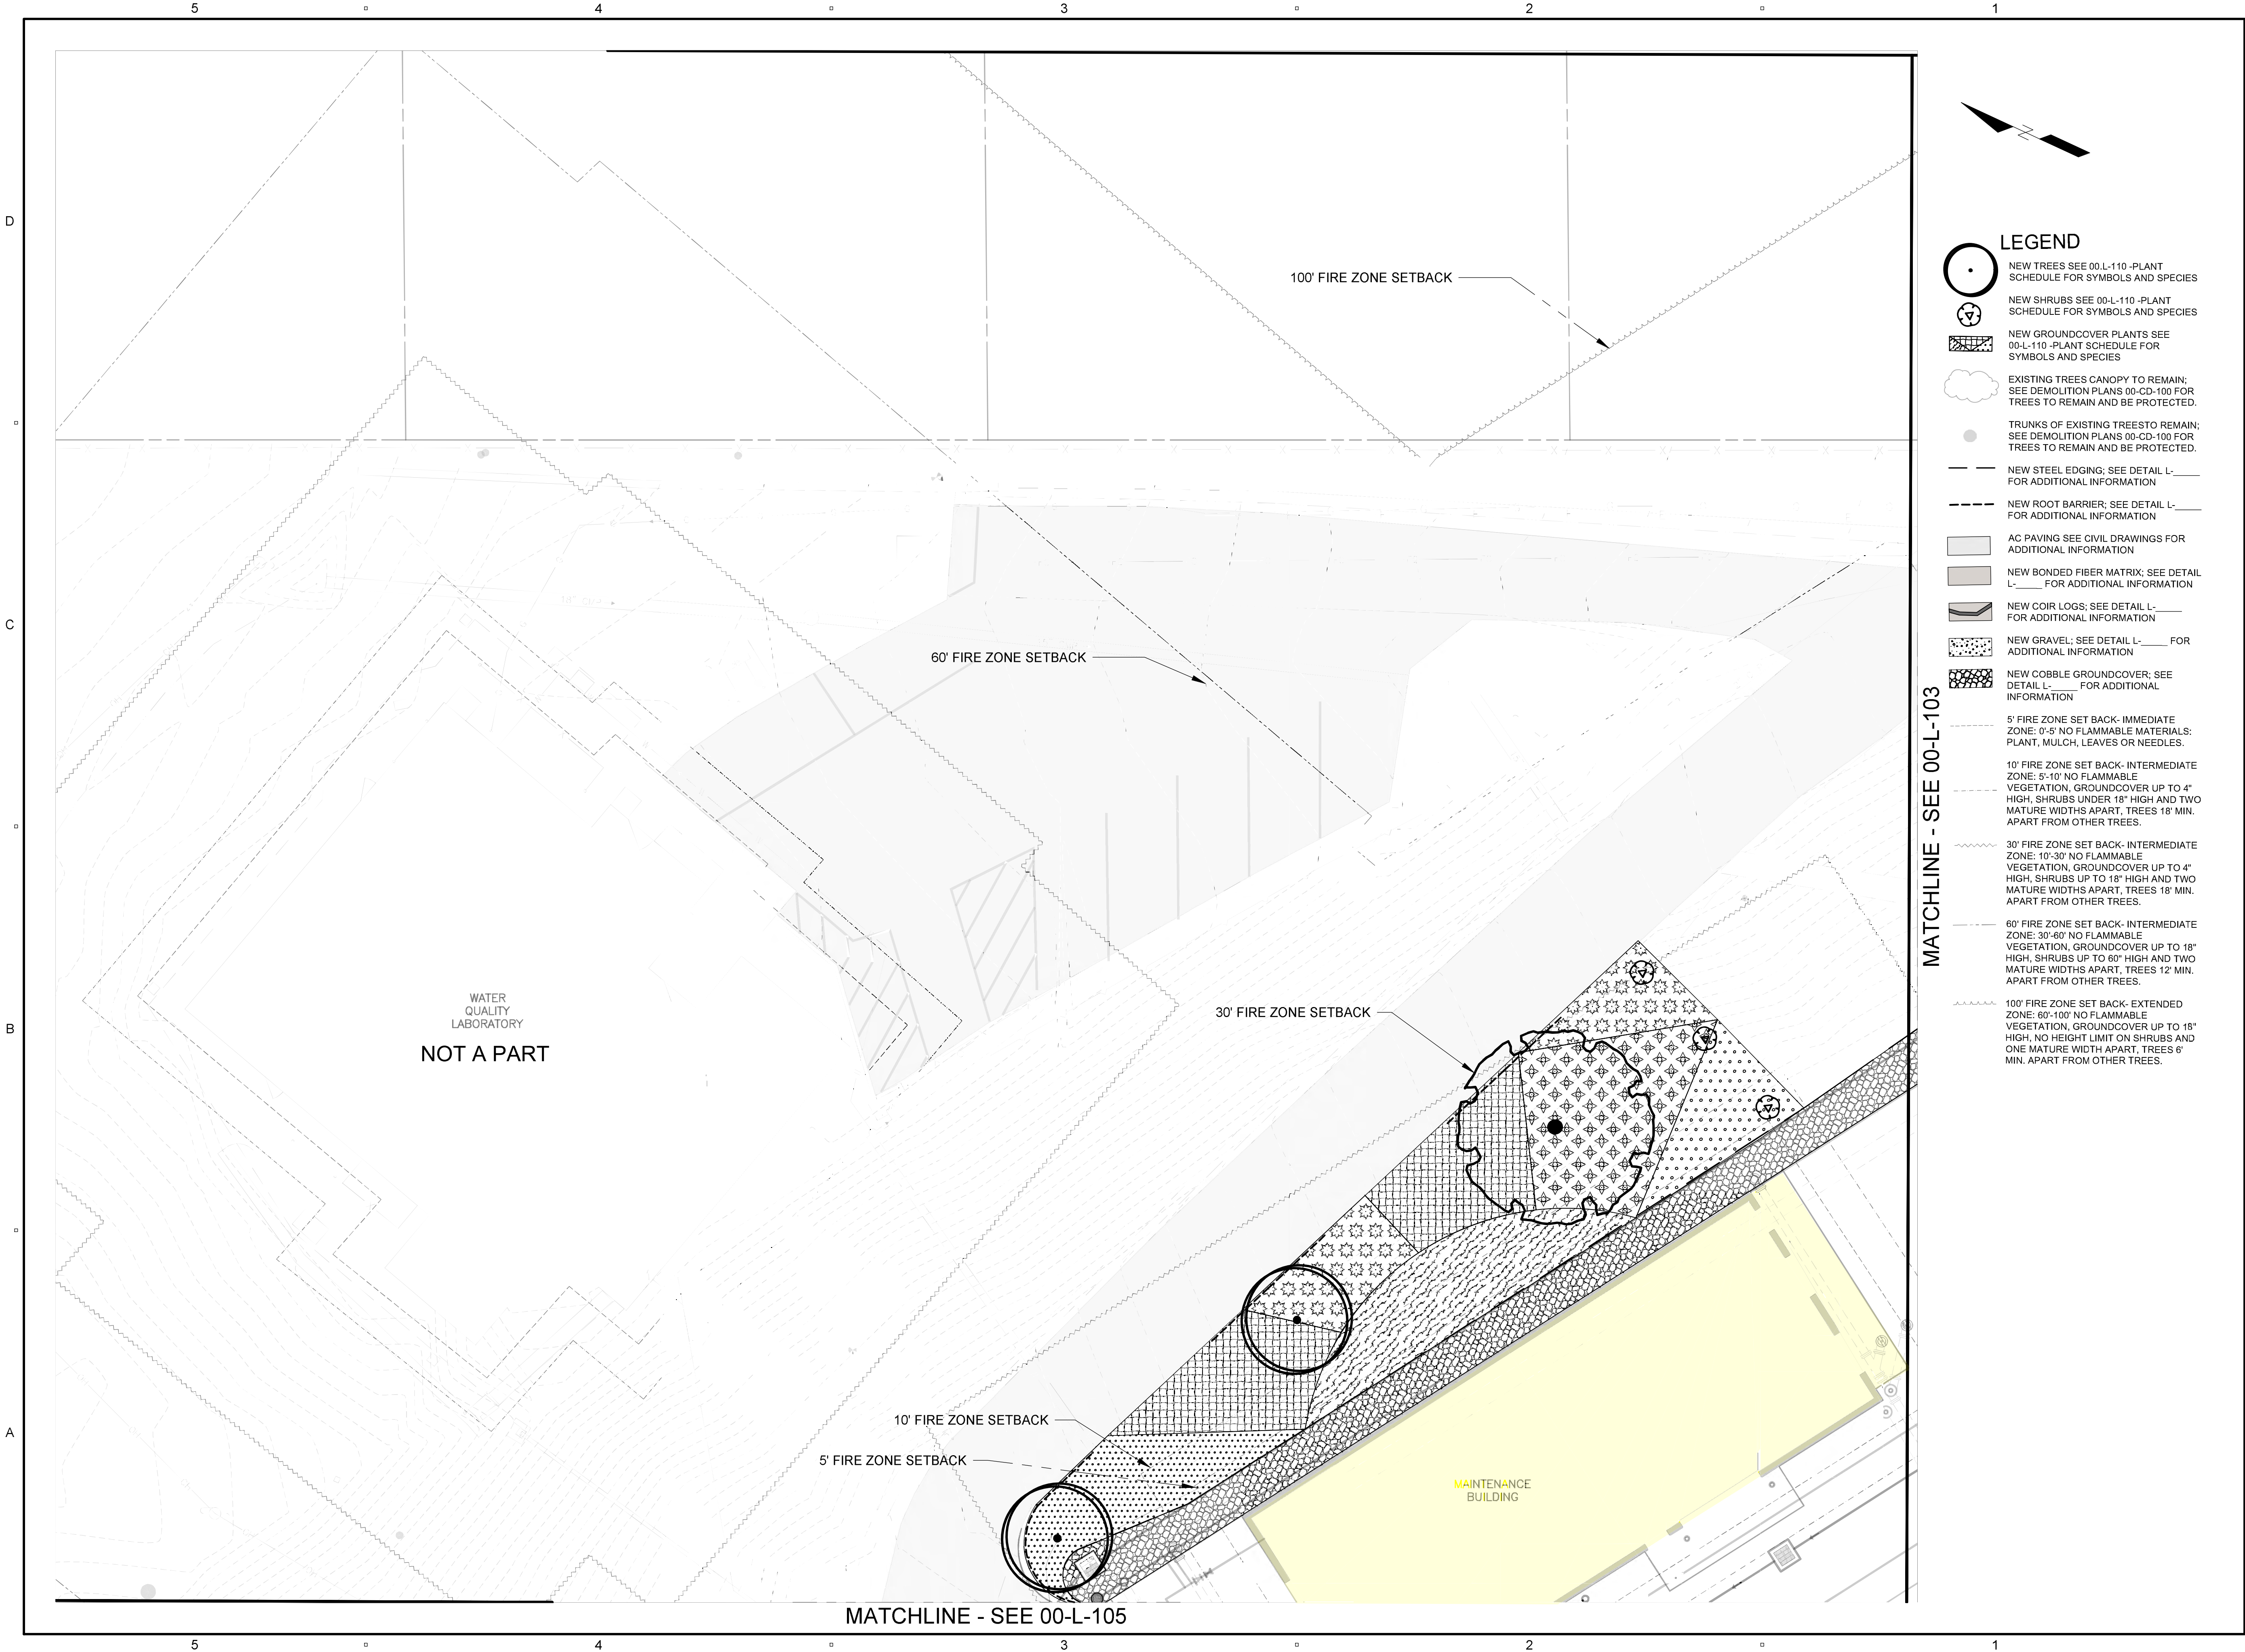


PROJECT
GRAHAM HILL WATER TREATMENT PLANT - FACILITY IMPROVEMENTS PROJECT
715 Graham Hill Rd,
Santa Cruz, CA 95060
APN 060-141-05

OWNER
CITY OF SANTA CRUZ WATER DEPARTMENT
212 Locust St Ste A,
Santa Cruz, CA 95060
Phone: (831) 420-5200

ENGINEER
AECOM TECHNICAL SERVICES, INC.
250 APOLLO DRIVE
CHELMSFORD, MA 01824
PHONE: (978) 905-2100
www.aecom.com
AECOM TECHNICAL SERVICES, INC.
2020 L STREET
SACRAMENTO, CA 95811
PHONE: (916) 414-5800
www.aecom.com

CONSULTANTS
KENNEDY JENKS (Design Assistance)
275 Battery Street, Suite 550
San Francisco, CA 94111
www.kennedyjenks.com
BOWMAN & WILLIAMS (Surveyor)
3949 Research Park Court, Suite 100
Soquel, CA 95073
www.bowmanandwilliams.com

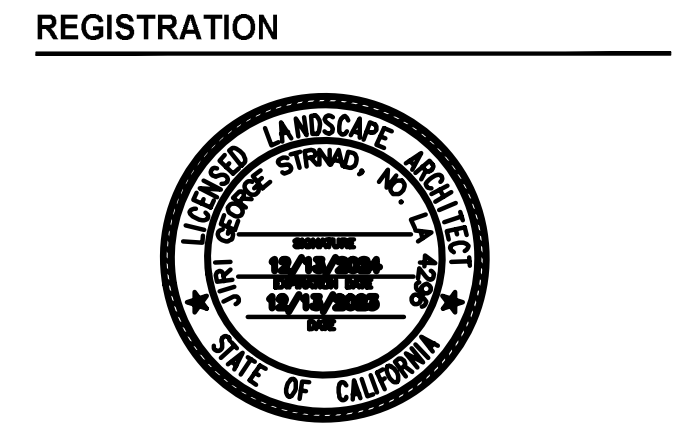


ISSUE/REVISION

I/R	DATE	DESCRIPTION

PROJECT NUMBER
60667213

Designed By:	GS
Drawn By:	MO
Dept Check:	GS
Proj Check:	G. PERIGAULT
Date:	DECEMBER 2023
Scale:	1" = 10'

DISCIPLINE
LANDSCAPE
SHEET TITLE
LANDSCAPE PLAN 2 OF 10

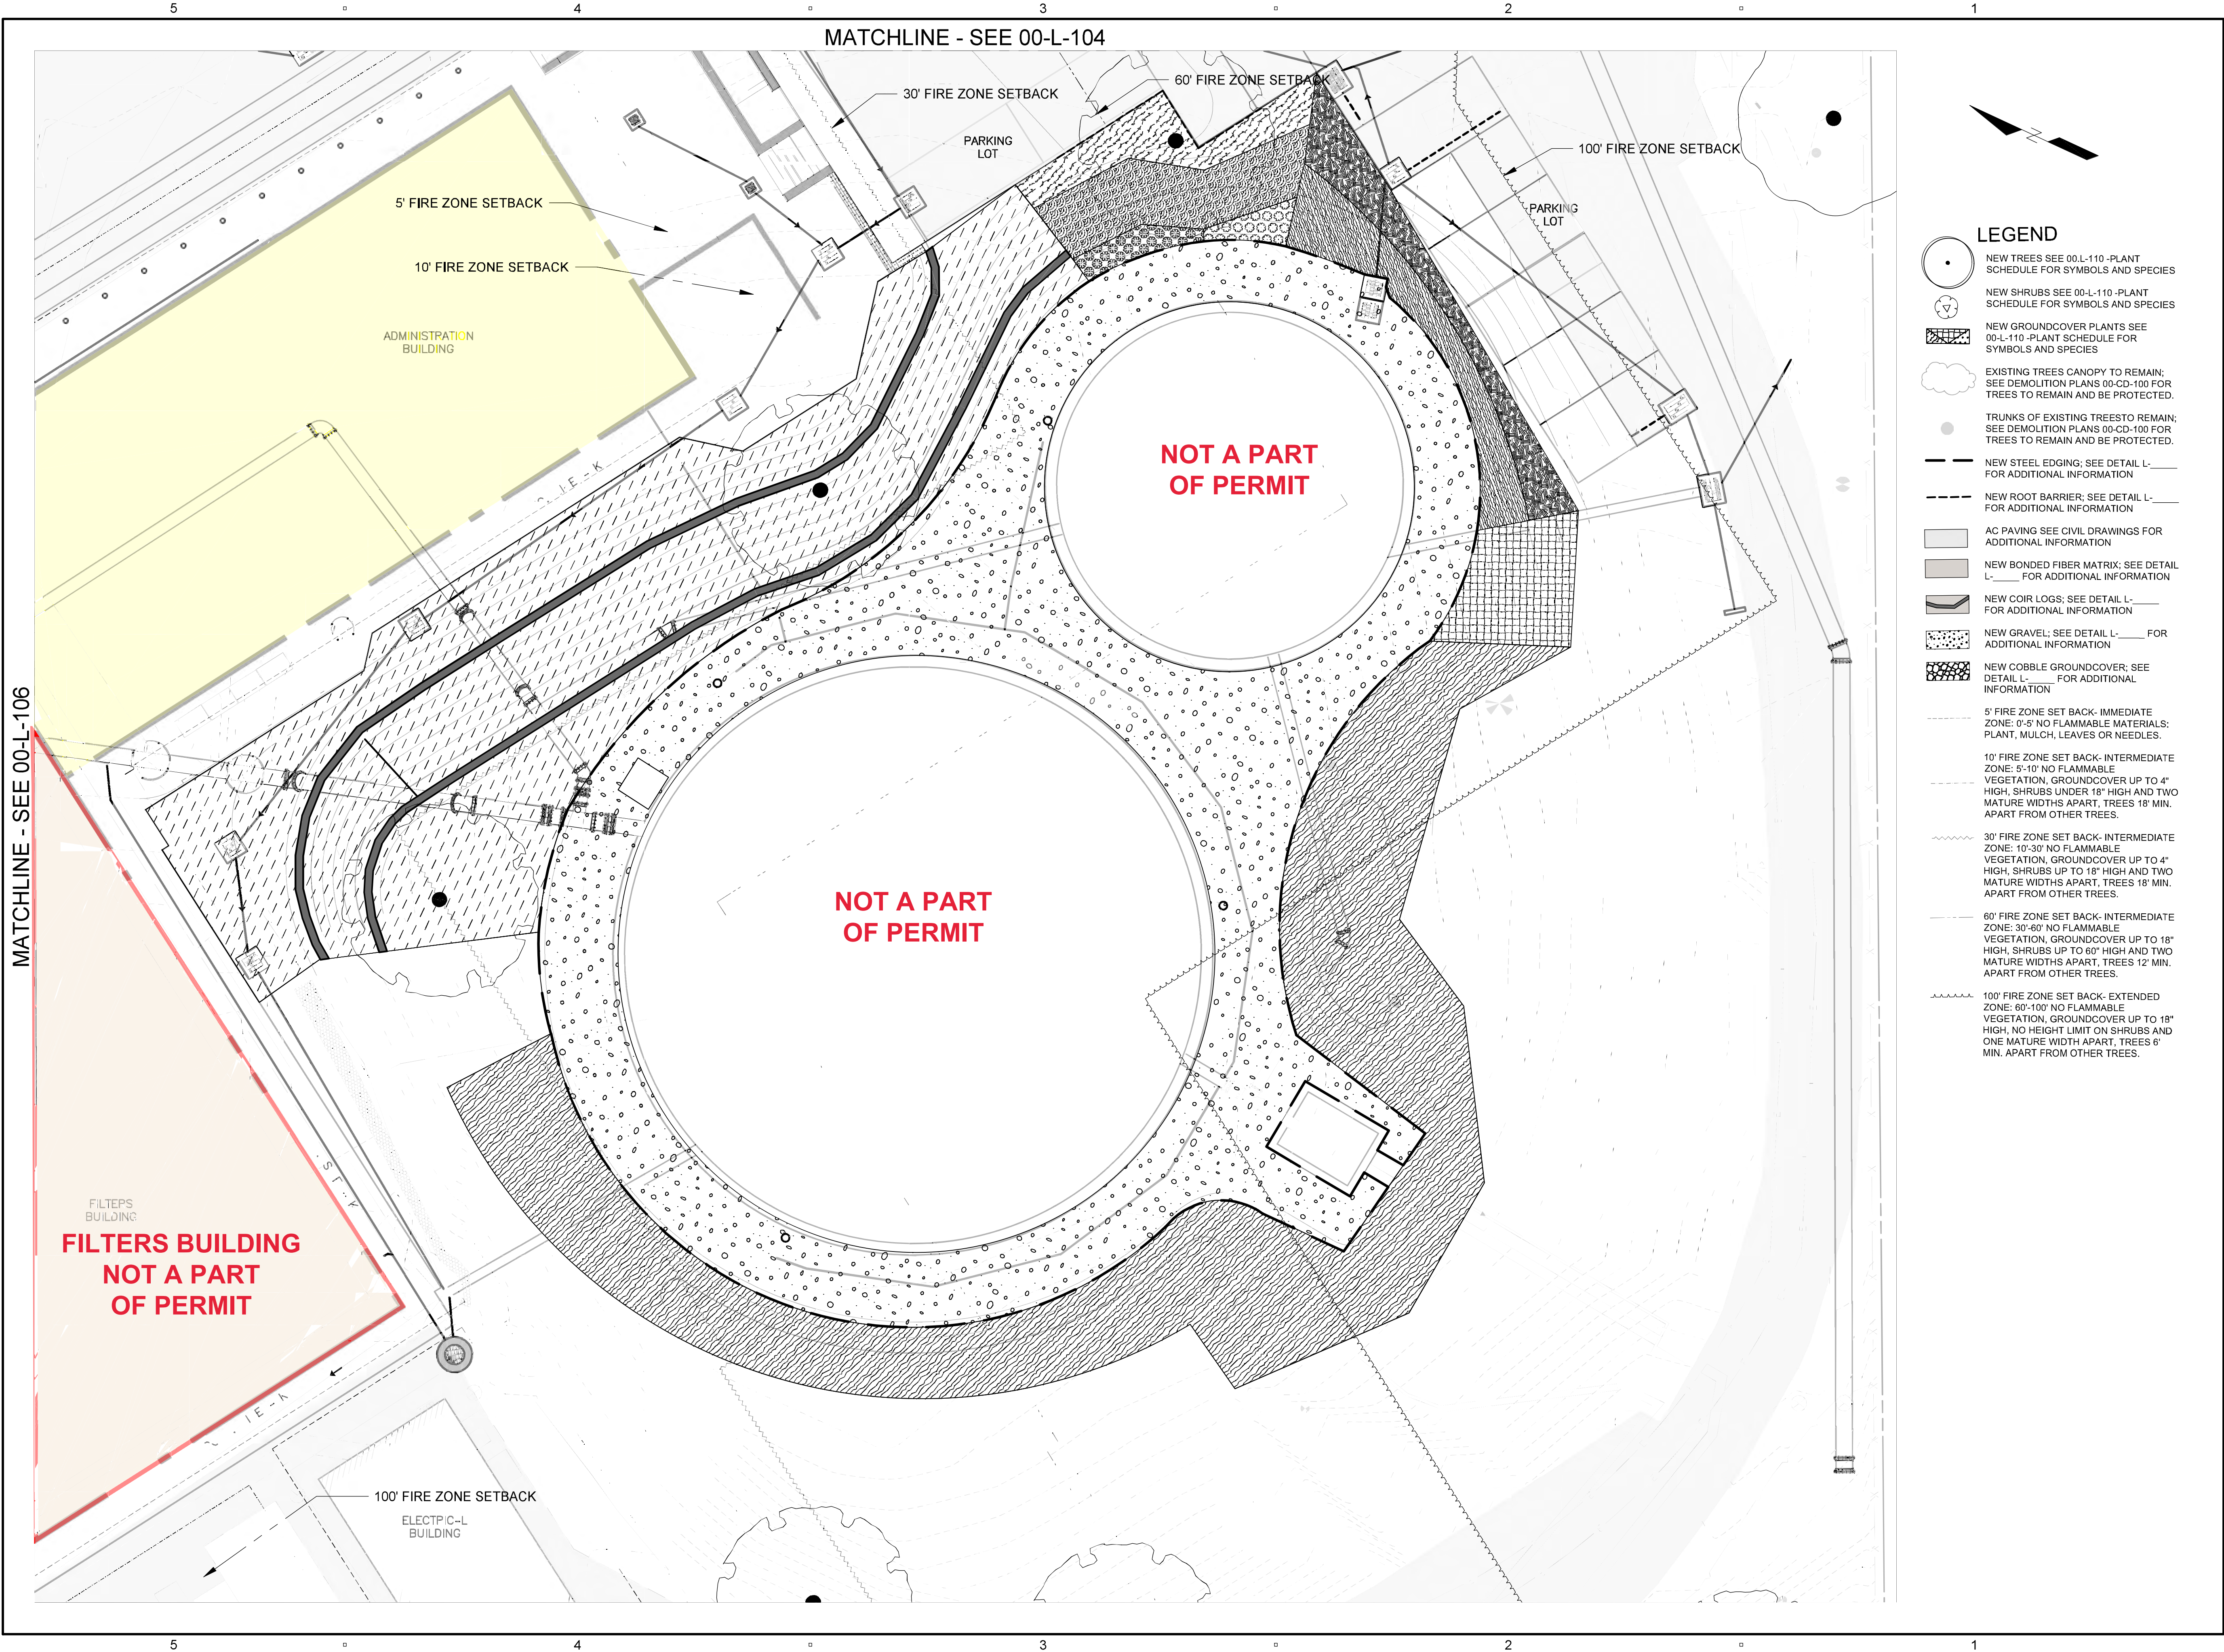

PROJECT

GRAHAM HILL WATER
TREATMENT PLANT - FACILITY
IMPROVEMENTS PROJECT

715 Graham Hill Rd,
Santa Cruz, CA 95060
APN 060-141-05

OWNER

CITY OF SANTA CRUZ
WATER DEPARTMENT

212 Locust St Ste A,
Santa Cruz, CA 95060
Phone: (831) 420-5200



ENGINEER

AECOM TECHNICAL SERVICES, INC.
250 APOLLO DRIVE
CHELMSFORD, MA 01824
PHONE: (978) 905-2100
www.aecom.com


AECOM TECHNICAL SERVICES, INC.
2020 L STREET
SACRAMENTO, CA 95811
PHONE: (916) 414-5800
www.aecom.com

CONSULTANTS

KENNEDY JENKS (Design Assistance)
275 Battery Street, Suite 550
San Francisco, CA 94111
www.kennedyjenks.com

BOWMAN & WILLIAMS (Surveyor)
3949 Research Park Court, Suite 100
Soquel, CA 95073
www.bowmanandwilliams.com

REGISTRATION

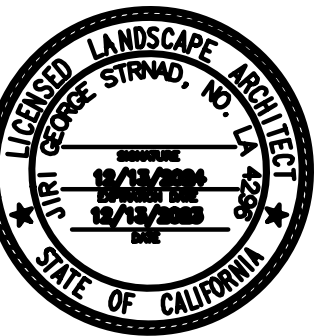

ISSUE/REVISION

I/R	DATE	DESCRIPTION
-----	------	-------------

PROJECT NUMBER

60667213

Designed By:	GS
Drawn By:	MO
Dept Check:	GS
Proj Check:	G. PERIGAULT
Date:	DECEMBER 2023
Scale:	1" = 10'

DISCIPLINE


LANDSCAPE

SHEET TITLE

LANDSCAPE PLAN
7 OF 10

SHEET NUMBER

00-L-107

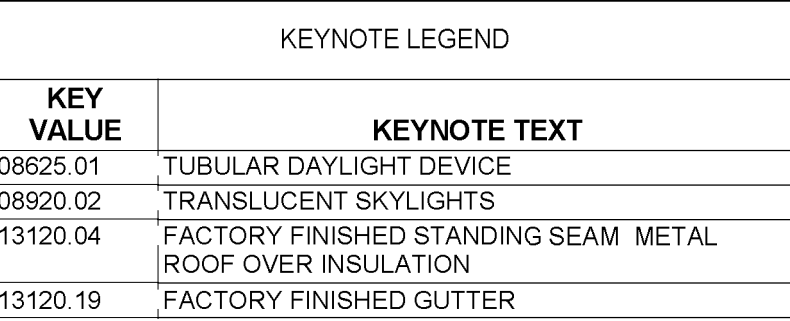

OWNER

212 Locust St Ste A
Santa Cruz, CA 95060
PHONE: (831) 420-5200


ENGINEER

AECOM TECHNICAL SERVICES, INC.
2020 L STREET
SACRAMENTO, CA 95811
PHONE: (916) 414-5800
www.aecom.com

CONSULTANTS

BOWMAN & WILLIAMS (Surveyor)
3949 Research Park Court, Suit 100
Soquel, CA 95073
www.bowmanandwilliams.com

REGISTRATION

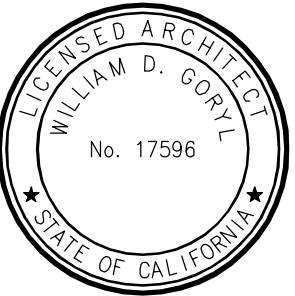

ISSUE/REVISION

I/R	DATE	DESCRIPTION

PROJECT NUMBER

60667213	
Designed By:	W. GORYL
Drawn By:	M. PICONE
Dept Check:	G. OTTERSON
Approved by:	G. PERIGAULT
Date:	DECEMBER 2023
Scale:	3/32" = 1'-0"

DISCIPLINE

ARCHITECTURAL
SHEET TITLE

ADMIN & OPS BUILDING - ROOF PLAN

SHEET NUMBER

30-32 A-106 PAGE 15 OF 21



GRAHAM HILL WATER TREATMENT PLANT - FACILITY IMPROVEMENTS PROJECT

715 Graham Hill Rd,
Santa Cruz, CA 95060
APN 060-141-05

CITY OF SANTA CRUZ
WATER DEPARTMENT

212 Locust St Ste A
Santa Cruz, CA 95060
PHONE: (831) 420-5200

AECOM TECHNICAL SERVICES, INC.
250 APOLLO DRIVE
CHELMSFORD, MA 01824
PHONE: (978) 905-2100
www.aecom.com

AECOM TECHNICAL SERVICES, INC.
2020 L STREET
SACRAMENTO, CA 95811
PHONE: (916) 414-5800
www.aecom.com

KENNEDY JENKS (Design assistance)
275 Battery Street, Suit 550
San Francisco, CA 94111
www.kennedyjenks.com

BOWMAN & WILLIAMS (Surveyor)
3949 Research Park Court, Suit 100
Soquel, CA 95073
www.bowmanandwilliams.com

A circular professional seal for William D. Goryl, a Licensed Architect in the State of California. The outer ring of the seal contains the text "LICENSED ARCHITECT" at the top and "STATE OF CALIFORNIA" at the bottom, separated by two small stars. Inside this ring, the name "WILLIAM D. GORYL" is written in a slightly smaller circle, and the number "No. 17596" is centered below the name.

I/R	DATE	DESCRIPTION

60667213

Designed By:	M. PICONE
Drawn By:	M. PICONE
Dept Check:	W. GORYL
Approved by:	G. PERIGAULT
Date:	DECEMBER 2023
Scale:	1/4" = 1'-0"

ARCHITECTURAL
SHEET TITLE

MAINTENANCE BUILDING - ROOF PLAN

85-A-102 **PAGE 16 OF 21**

5 4 3 2 1

D


C

B

A

5 4 3 2 1

PATH: I:\PROJECTS\2023\00-CD-103\00-CD-103.dwg
LAST UPDATE: 12/13/2023 11:01:22 AM
PLOT DATE: 12/14/2023 2:46:39 PM

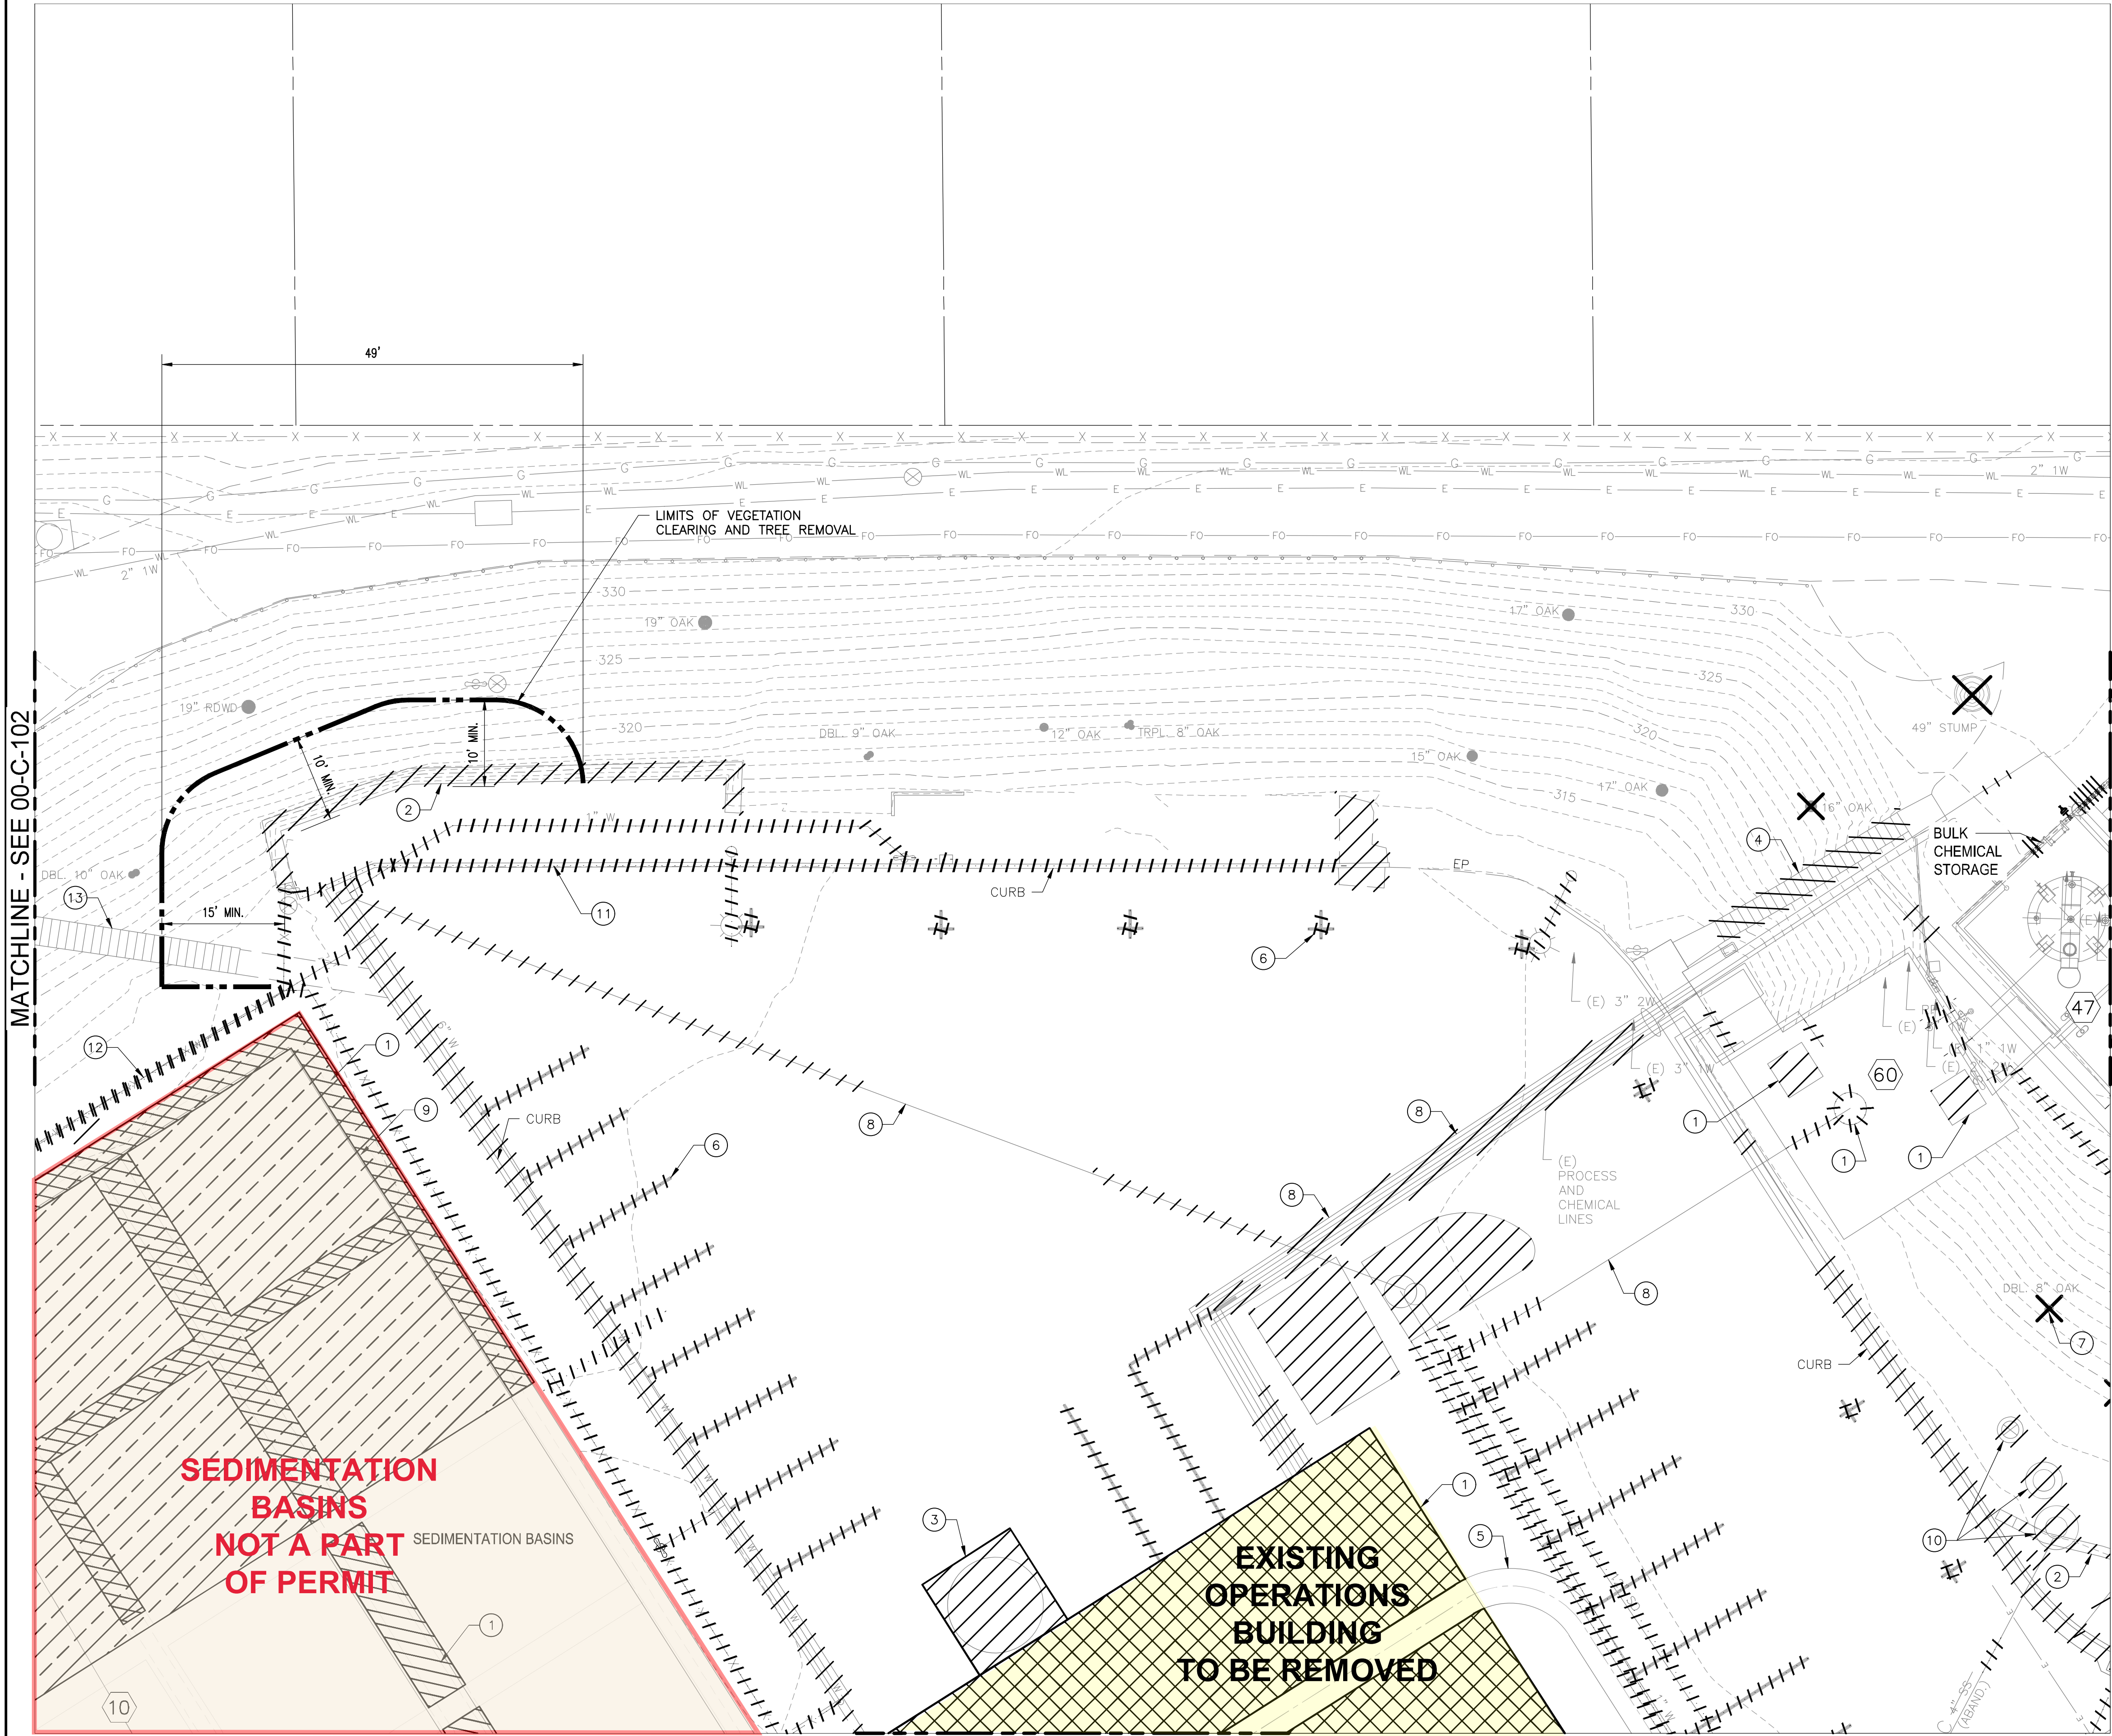

LEGEND


- DEMOLISH EXISTING FEATURE.
- REMOVE STRUCTURE 4 FT BELOW EXISTING GRADE. BREAK BOTTOM SLAB OF STRUCTURE. CORE BOTTOM SLAB WITH 6-INCH CORES EVERY 3 FT IN CHECKERED PATTERN FOR DRAINAGE.
- DEMOLISH STRUCTURE AND SLAB ON GRADE FOOTING.
- REMOVE TREE.

NOTES:

- SEE AREA DESIGNATION KEY PLAN ON SHEET 00-C-004 FOR STRUCTURE DESIGNATION.

CODED NOTES:

- REFER TO OTHER DISCIPLINES' DRAWING FOR EXTENT OF DEMOLITION AND ADDITIONAL DEMOLITION REQUIREMENTS.
- RETAINING WALL WILL BE MOVED BY OWNER PRIOR TO START OF WORK.
- DEMOLISH SODIUM HYPOCHLORITE DAY TANK AND CONCRETE EQUIPMENT PAD.
- REMOVE AND REPLACE EXISTING STAIRS AND HANDRAIL.
- PROTECT EXISTING 48" SETTLED WATER PIPE AND ENCASEMENT AT ALL TIMES DURING CONSTRUCTION.
- REMOVE PARKING STRIPING (TYP.).
- REMOVE TREE/STUMP (TYP.).
- REMOVE EXISTING PIPING AS REQUIRED FOR NEW WORK INSTALLATION. ABANDON REMAINING PIPING IN PLACE (TYP.).
- REMOVE HOSE BIBB (TYP.).
- REMOVE SEPTIC TANK (ABANDONED).
- REMOVE CURB.
- REMOVE FENCE.
- PROTECT EXISTING STAIRS AT ALL TIMES DURING CONSTRUCTION.

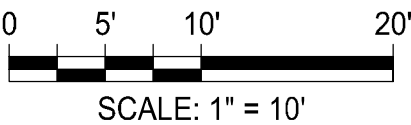

PROJECT

GRAHAM HILL WATER TREATMENT PLANT - FACILITY IMPROVEMENTS PROJECT

715 Graham Hill Rd,
Santa Cruz, CA 95060
APN 060-141-05

OWNER

CITY OF SANTA CRUZ WATER DEPARTMENT

212 Locust St Ste A,
Santa Cruz, CA 95060
Phone: (831) 420-5200



ENGINEER

AECOM TECHNICAL SERVICES, INC.
250 APOLLO DRIVE
CHELMSFORD, MA 01824
PHONE: (978) 905-2100
www.aecom.com

AECOM TECHNICAL SERVICES, INC.
2020 L STREET
SACRAMENTO, CA 95811
PHONE: (916) 414-5800
www.aecom.com

CONSULTANTS

KENNEDY JENKS (Design Assistance)
275 Battery Street, Suite 550
San Francisco, CA 94111
www.kennedyjenks.com

BOWMAN & WILLIAMS (Surveyor)
3949 Research Park Court, Suite 100
Soquel, CA 95073
www.bowmanandwilliams.com

REGISTRATION



ISSUE/REVISION

I/R	DATE	DESCRIPTION

PROJECT NUMBER

60667213

Designed By:	WT
Drawn By:	ZB
Dept Check:	LR
Proj Check:	G. PERIGAULT
Date:	DECEMBER 2023
Scale:	1" = 10'

DISCIPLINE

CIVIL

SHEET TITLE

SITE DEMOLITION PLAN 3 OF 7

SHEET NUMBER

00-CD-103 PAGE 17 OF 27

MATCHLINE - SEE 00-CD-103

MATCHLINE - SEE 00-C-105

MATCHLINE - SEE 00-C-107

SEDIMENTATION
BASINS
NOT A PART
OF PERMIT

EXISTING
OPERATIONS
BUILDING
TO BE REMOVED

EXISTING
OPERATIONS
BUILDING
TO BE REMOVED
& RECONSTRUCTED

FILTERS
BUILDING
NOT A PART
OF PERMIT

LEGEND


- DEMOLISH EXISTING FEATURE.
- DEMOLISH STRUCTURE AND SLAB ON GRADE FOOTING.
- REMOVE STRUCTURE ABOVE BASEMENT TOP SLAB ONLY. SEE STRUCTURAL DRAWINGS FOR EXTENT OF DEMOLITION.

NOTES:

1. SEE AREA DESIGNATION KEY PLAN ON SHEET 00-C-004 FOR STRUCTURE DESIGNATION.

CODED NOTES:

- 1 REFER TO OTHER DISCIPLINES' DRAWING FOR EXTENT OF DEMOLITION AND ADDITIONAL DEMOLITION REQUIREMENTS.
- 2 DEMOLISH EXISTING UTILITIES AS REQUIRED FOR INSTALLATION OF NEW WORK.
- 3 PROTECT EXISTING 48" SETTLED WATER PIPE AND ENCASEMENT AT ALL TIMES DURING CONSTRUCTION.
- 4 REMOVE PARKING STRIPING (TYP.).
- 5 ABANDON IN PLACE.
- 6 REMOVE HOSE BIBB.
- 7 DEMOLISH EXISTING CHEMICAL PIPING TRENCHES.
- 8 REMOVE ELECTRICAL CONDUITS.
- 9 REMOVE FENCE.
- 10 FIELD VERIFY LOCATION OF PIPE.

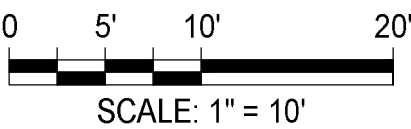

PROJECT

GRAHAM HILL WATER
TREATMENT PLANT - FACILITY
IMPROVEMENTS PROJECT
715 Graham Hill Rd,
Santa Cruz, CA 95060
APN 060-141-05

OWNER

CITY OF SANTA CRUZ
WATER DEPARTMENT

212 Locust St Ste A,
Santa Cruz, CA 95060
Phone: (831) 420-5200



ENGINEER

AECOM TECHNICAL SERVICES, INC.
250 APOLLO DRIVE
CHELMSFORD, MA 01824
PHONE: (978) 905-2100
www.aecom.com

AECOM TECHNICAL SERVICES, INC.
2020 L STREET
SACRAMENTO, CA 95811
PHONE: (916) 414-5800
www.aecom.com

CONSULTANTS

KENNEDY JENKS (Design Assistance)
275 Battery Street, Suite 550
San Francisco, CA 94111
www.kennedyjenks.com

BOWMAN & WILLIAMS (Surveyor)
3949 Research Park Court, Suite 100
Soquel, CA 95073
www.bowmanandwilliams.com

REGISTRATION



ISSUE/REVISION

I/R	DATE	DESCRIPTION

PROJECT NUMBER

60667213

Designed By:	WT
Drawn By:	ZB
Dept Check:	LR
Proj Check:	G. PERIGAULT
Date:	DECEMBER 2023
Scale:	1" = 10'

DISCIPLINE

CIVIL
SHEET TITLE

SITE DEMOLITION PLAN
6 OF 7

SHEET NUMBER

00-CD-106 PAGE 18 OF 27

PROJECT

**GRAHAM HILL WATER
TREATMENT PLANT - FACILITY
IMPROVEMENTS PROJECT**

715 Graham Hill Rd,
Santa Cruz, CA 95060
APN 060-141-05

OWNER

**CITY OF SANTA CRUZ
WATER DEPARTMENT**

212 Locust St Ste A,
Santa Cruz, CA 95060
Phone: (831) 420-5200



ENGINEER

AECOM TECHNICAL SERVICES, INC.
250 APOLLO DRIVE
CHELMSFORD, MA 01824
PHONE: (978) 905-2100
www.aecom.com

AECOM TECHNICAL SERVICES, INC.
2020 L STREET
SACRAMENTO, CA 95811
PHONE: (916) 414-5800
www.aecom.com

CONSULTANTS

KENNEDY JENKS (Design Assistance)
275 Battery Street, Suite 550
San Francisco, CA 94111
www.kennedyjenks.com

BOWMAN & WILLIAMS (Surveyor)
3949 Research Park Court, Suite 100
Soquel, CA 95073
www.bowmanandwilliams.com

REGISTRATION



ISSUE/REVISION

I/R	DATE	DESCRIPTION

PROJECT NUMBER

60667213

Designed By:	A. CATALANO
Drawn By:	A. CATALANO
Dept Check:	M. MALENFANT
Proj Check:	G. PERIGAULT
Date:	DECEMBER 2023
Scale:	AS NOTED

DISCIPLINE


STRUCTURAL

SHEET TITLE


**FILTER & OPERATIONS
BLDG. - DEMOLITION PLAN**

SHEET NUMBER




25-32-SD-101 PAGE 19 OF 27

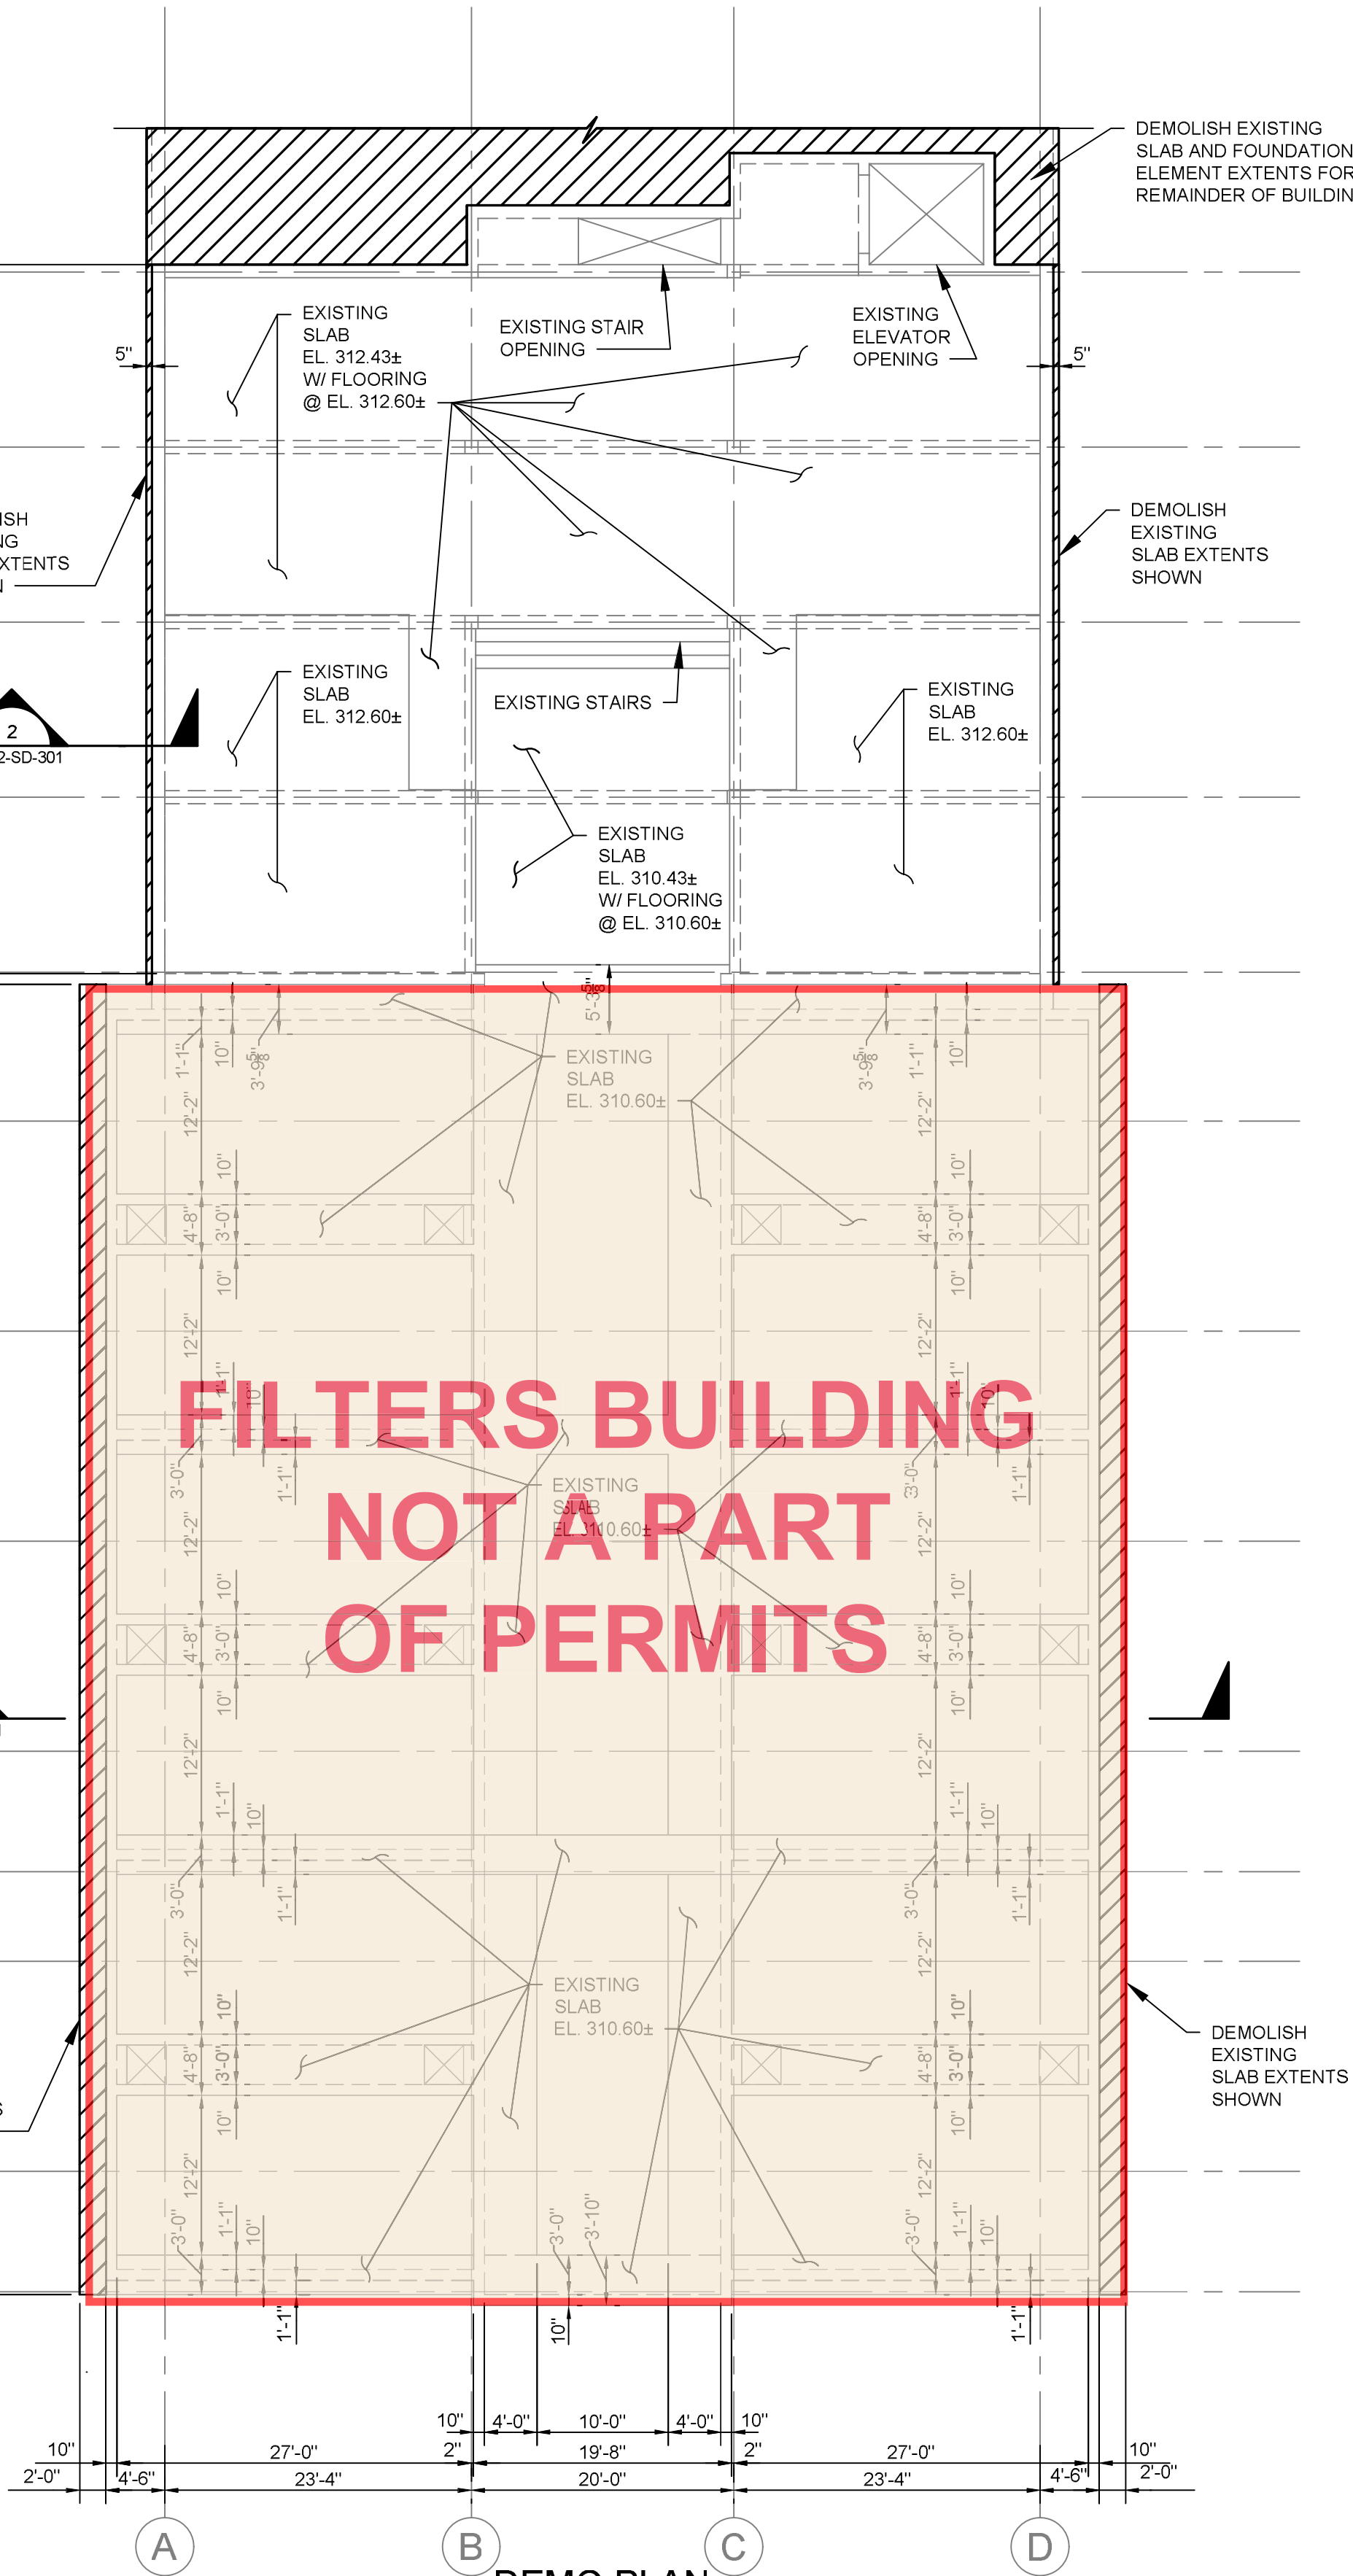

DEMO PLAN
3/32" = 1'-0"
NOTE: SUPERSTRUCTURES SHALL BE DEMOLISHED IN THEIR ENTIRETY.

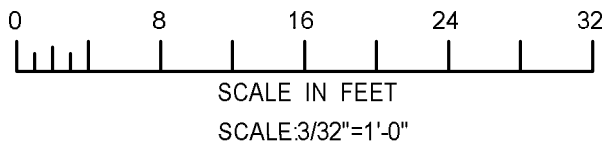

PATH\\FILENAME: L:\DCS\PROJECTS\WTR\6067213_SANTA_CRUZ_GRAHAM_HILL\900_CAD\SS\910_CAD\20\SHEETS\SS\25-32-SD-301.DWG
LAST UPDATE: Wednesday, December 13, 2023 7:48:22 AM
PLOT DATE: Wednesday, December 13, 2023 10:39:20 AM

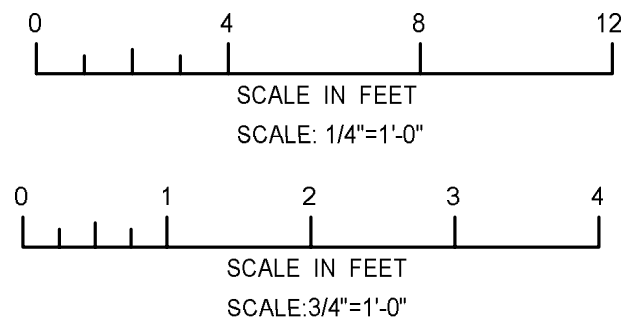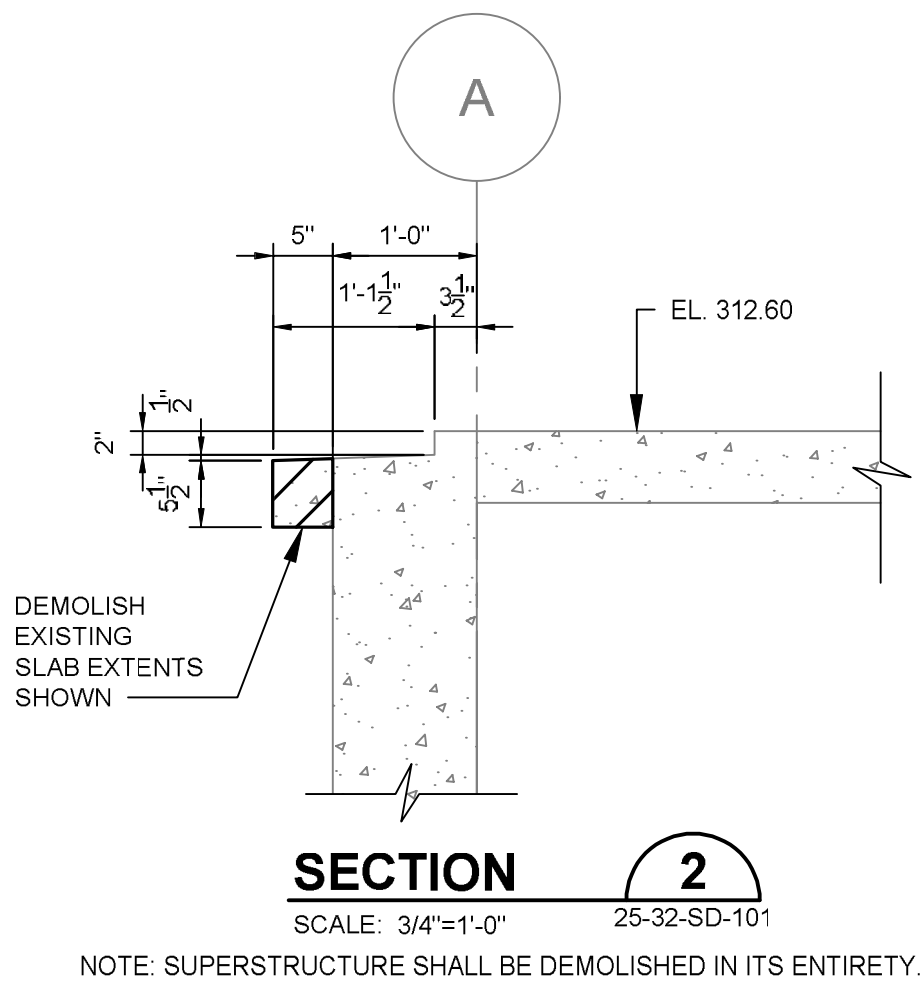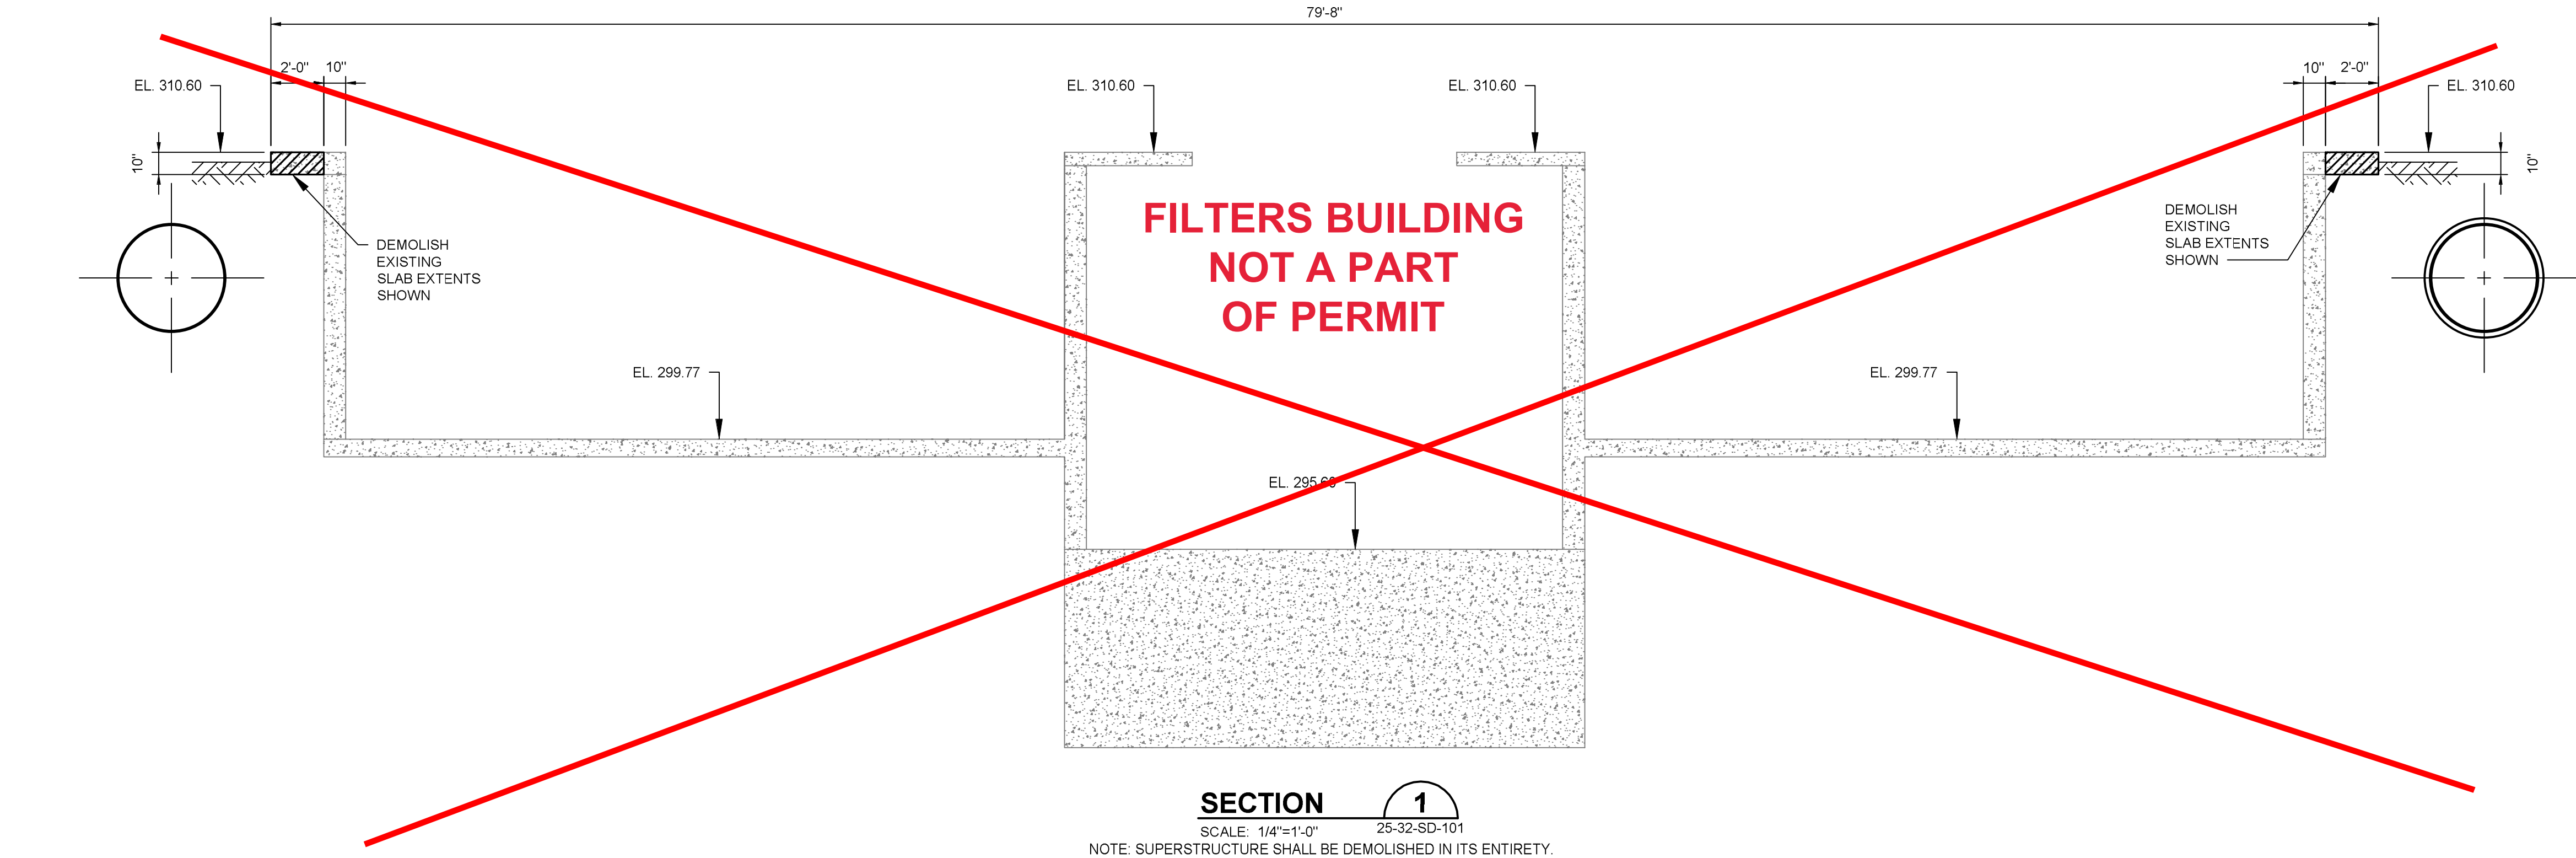

PROJECT

**GRAHAM HILL WATER
TREATMENT PLANT - FACILITY
IMPROVEMENTS PROJECT**
715 Graham Hill Rd,
Santa Cruz, CA 95060
APN 060-141-05

OWNER

**CITY OF SANTA CRUZ
WATER DEPARTMENT**
212 Locust St Ste A,
Santa Cruz, CA 95060
Phone: (831) 420-520C



ENGINEER

AECOM TECHNICAL SERVICES, INC.
250 APOLLO DRIVE
CHELMSFORD, MA 01824
PHONE: (978) 905-2100
www.aecom.com

AECOM TECHNICAL SERVICES, INC.
2020 L STREET
SACRAMENTO, CA 95811
PHONE: (916) 414-5800
www.aecom.com

CONSULTANTS

KENNEDY JENKS (Design Assistance)
275 Battery Street, Suite 550
San Francisco, CA 94111
www.kennedyjenks.com

BOWMAN & WILLIAMS (Surveyor)
3949 Research Park Court, Suite 100
Soquel, CA 95073
www.bowmanandwilliams.com

REGISTRATION



ISSUE/REVISION

I/R	DATE	DESCRIPTION

PROJECT NUMBER


Designed By:	A. CATALANO
Drawn By:	A. CATALANO
Dept Check:	M. MALENFANT
Proj Check:	G. PERIGAULT
Date:	DECEMBER 2023
Scale:	AS NOTED

DISCIPLINE



**STRUCTURAL
SHEET TITLE**

**FILTER & OPERATIONS
BLDG. - DEMOLITION
SECTIONS
SHEET NUMBER**

PATH\\FILENAME: Autodesk Docs\\60667213-GHWTP_FIP30-32-A-Admin & Operations Buildings.rvt
PLOT DATE: 12/13/2023 12:46:07 PM
PAGE 18 OF 26

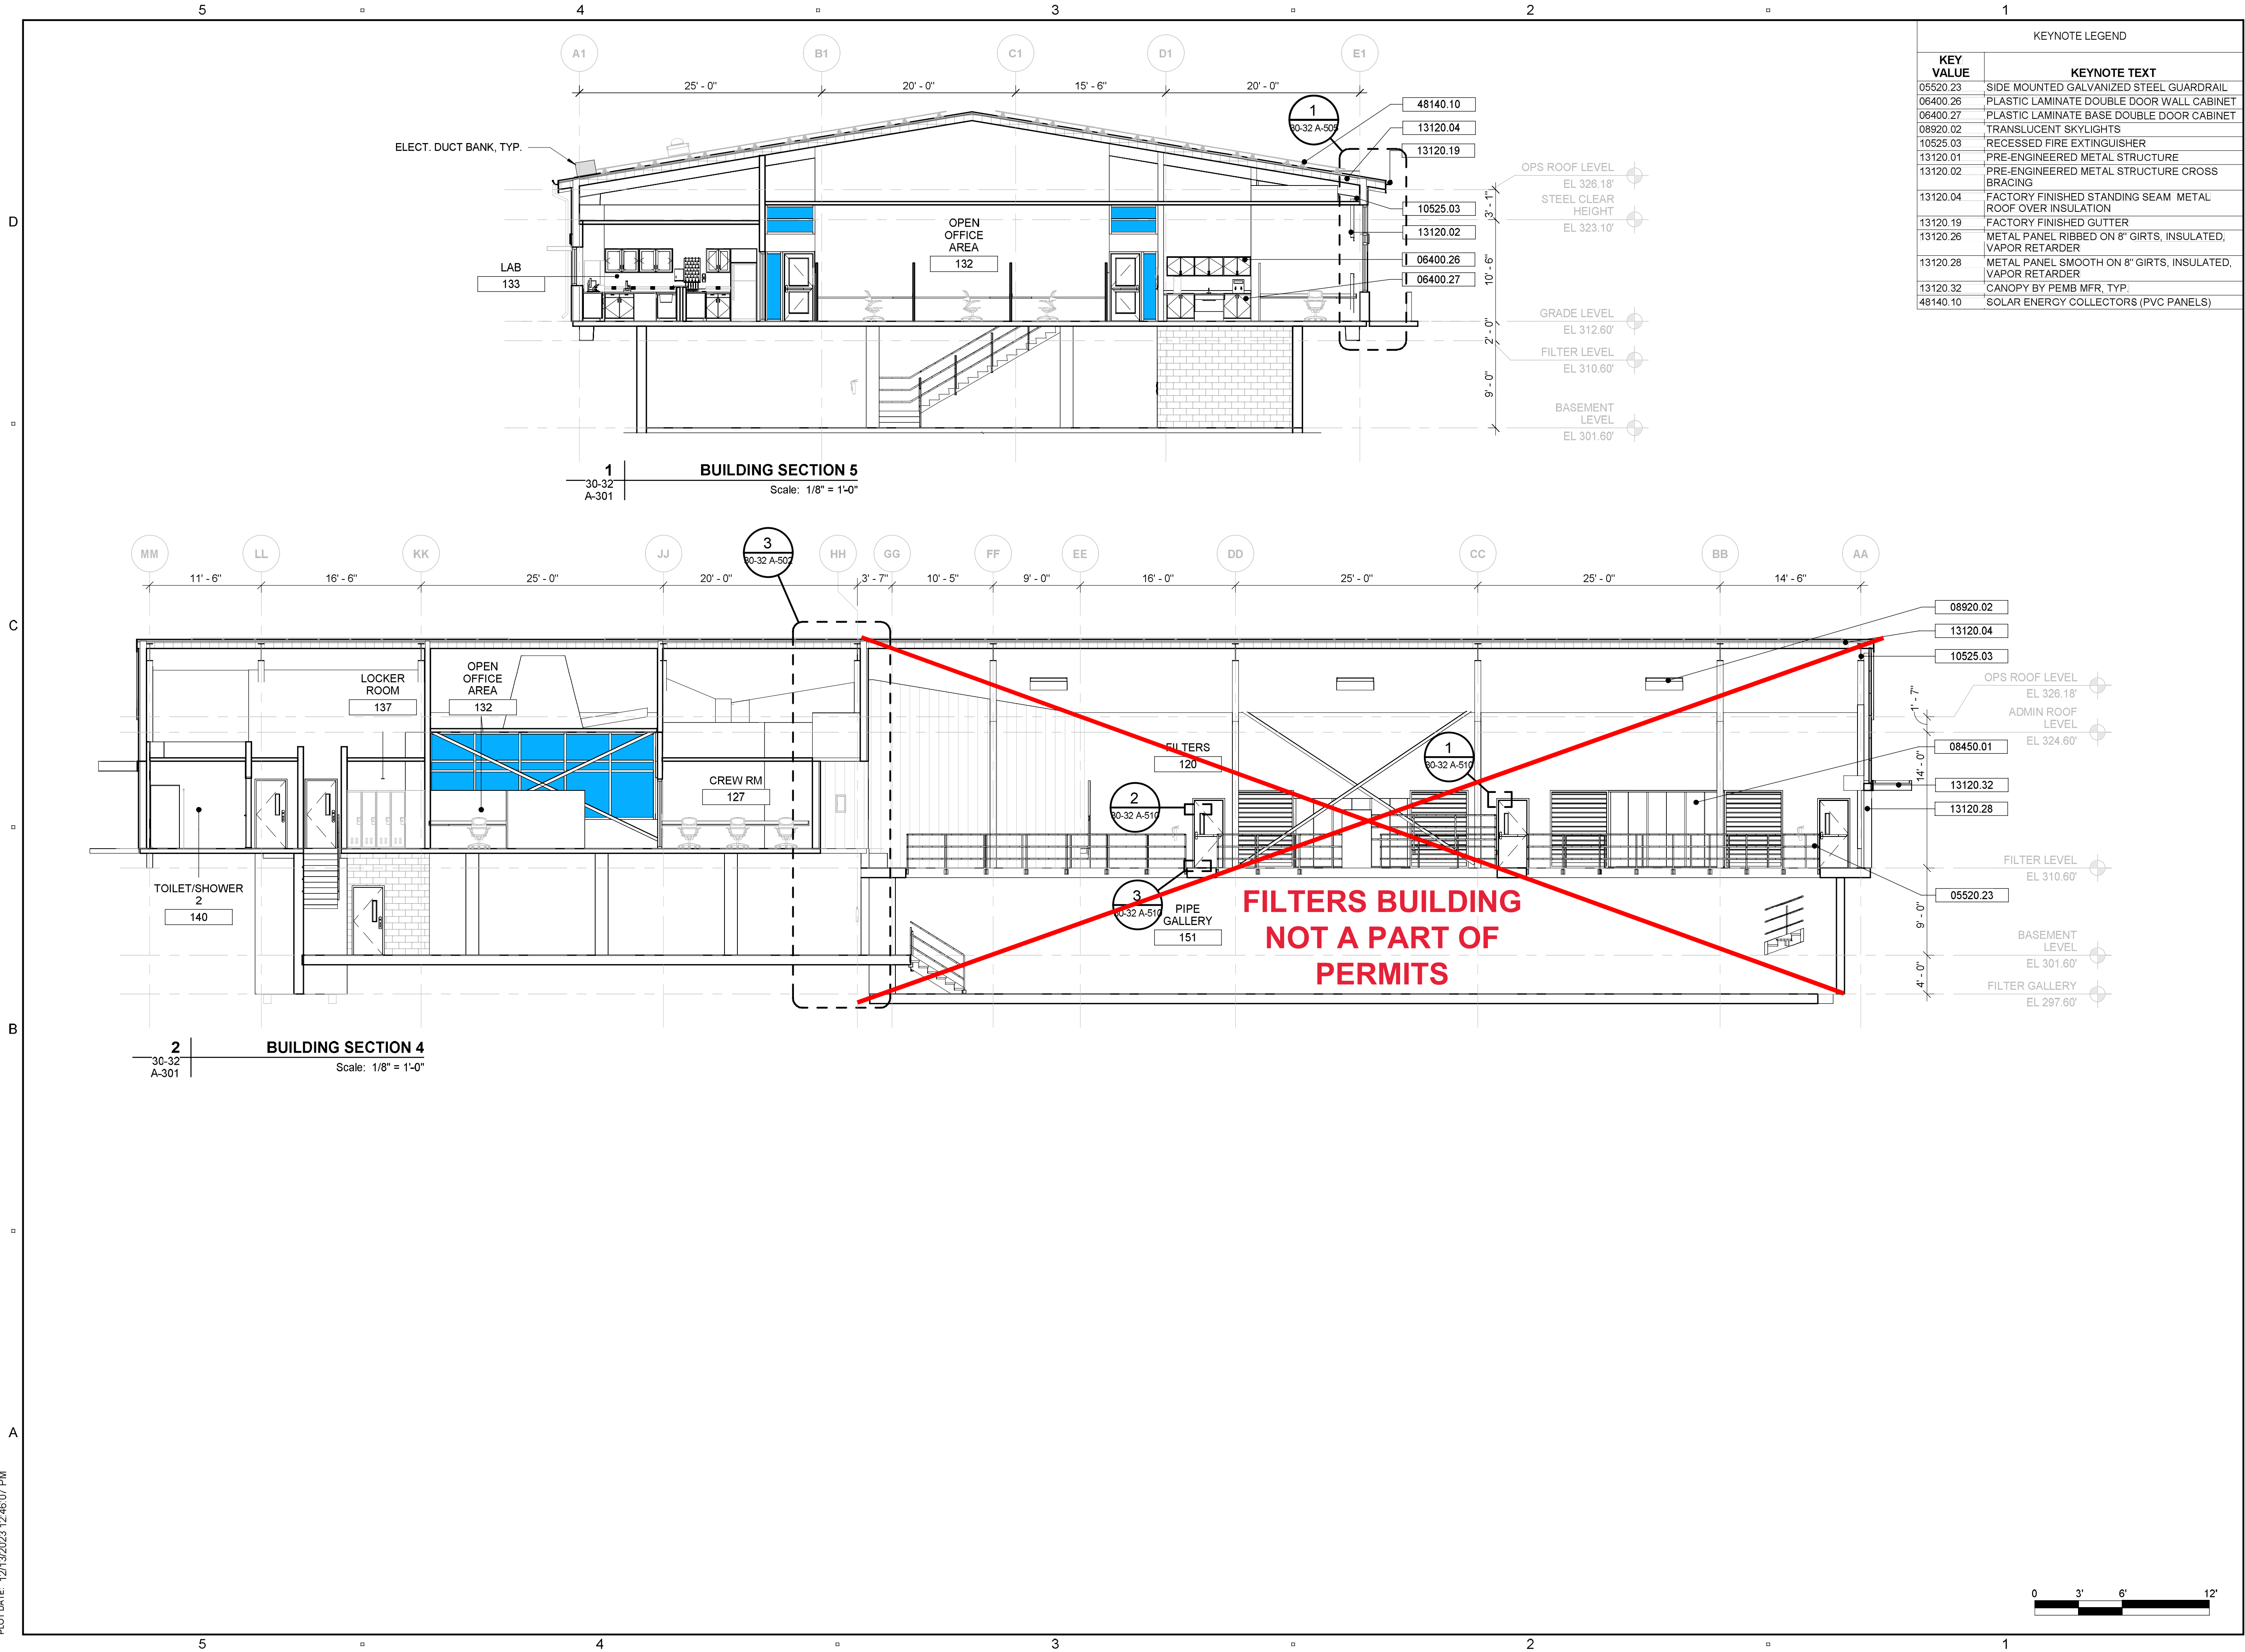

PATH\\FLEN\\AECOM\\Autodesk Docs\\60667213-GH\\WTP_FIP\\30-32-A-Admin & Operations Buildings.rvt
LAST UPDATE: 12/13/2023 12:46:41 PM
PLOT DATE: 12/13/2023 12:46:41 PM

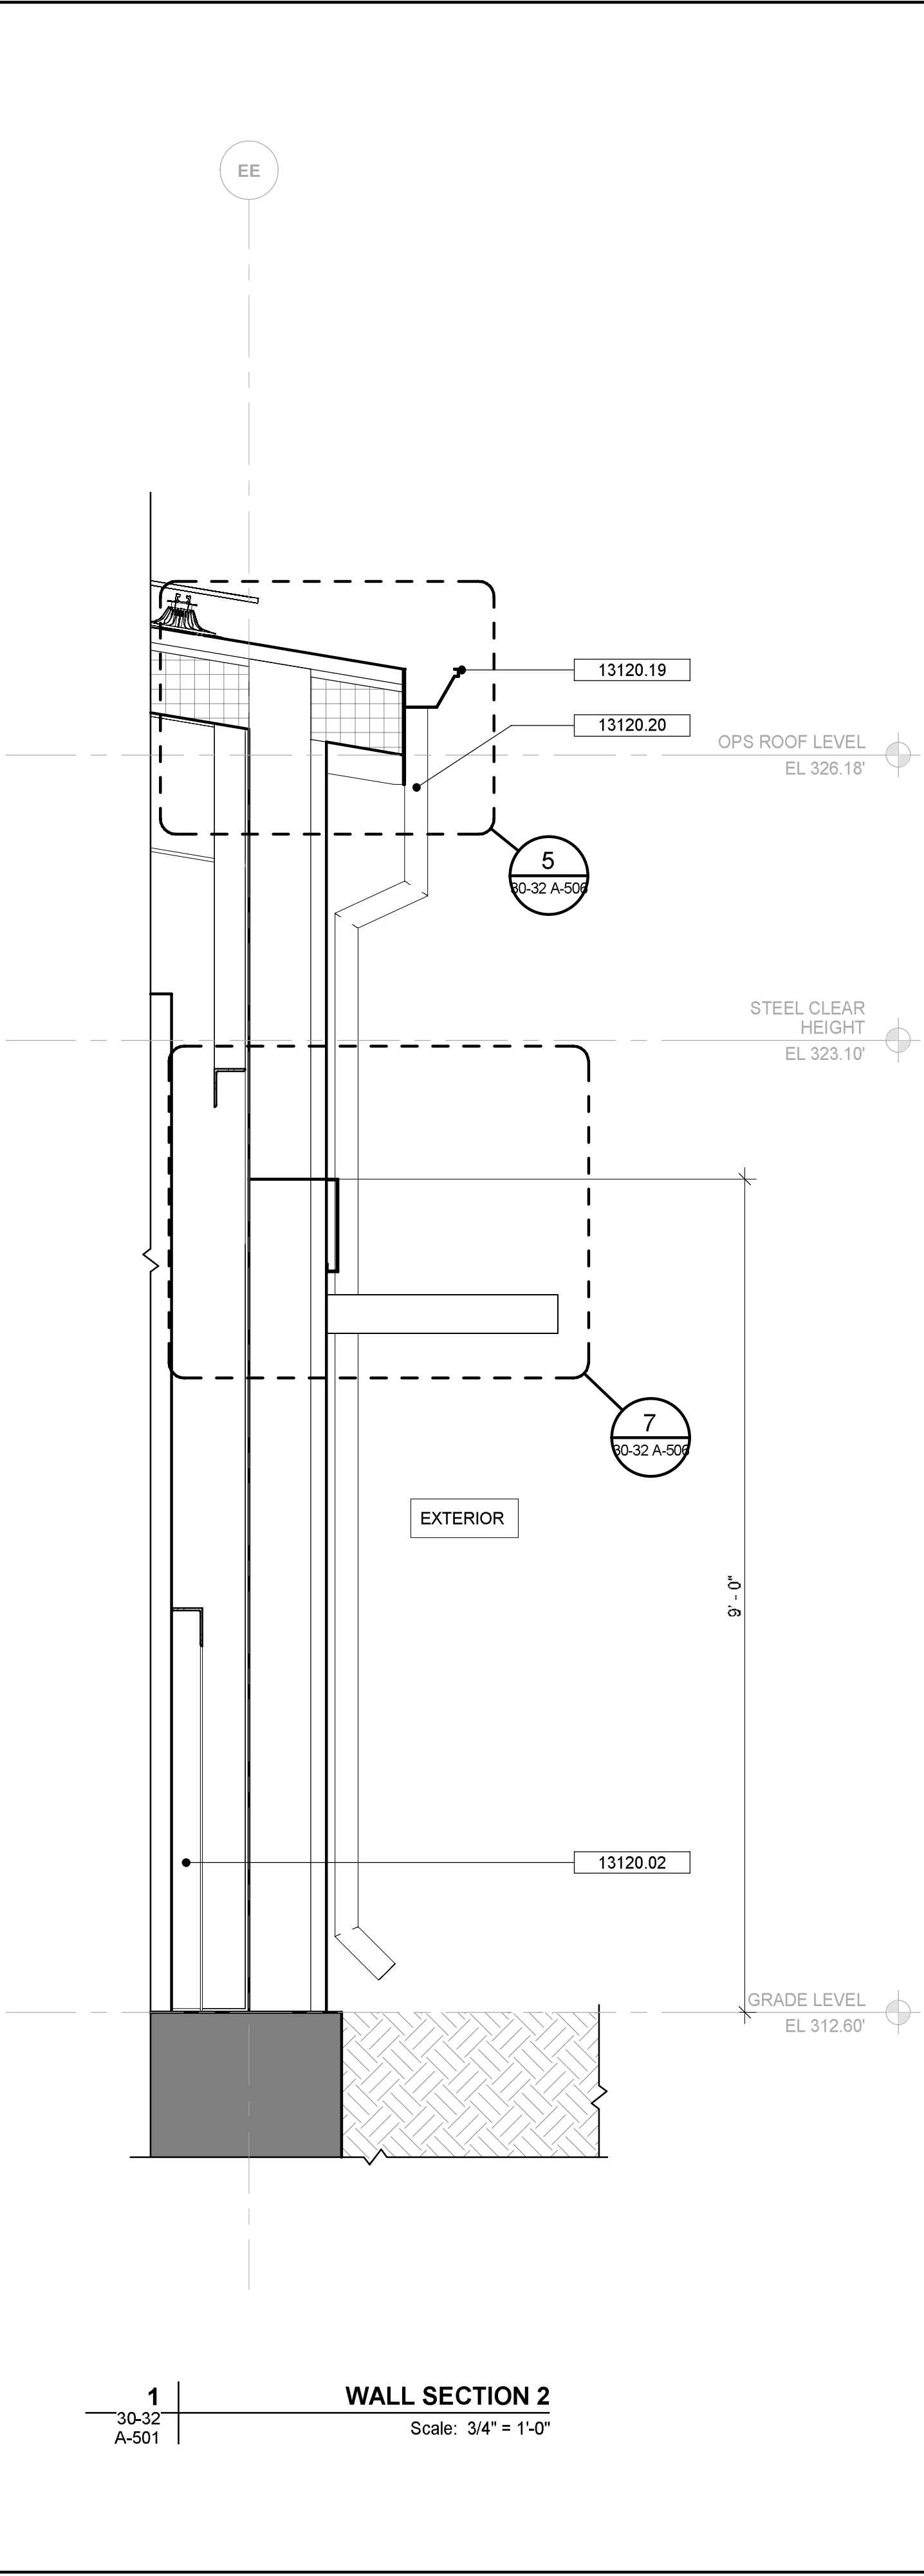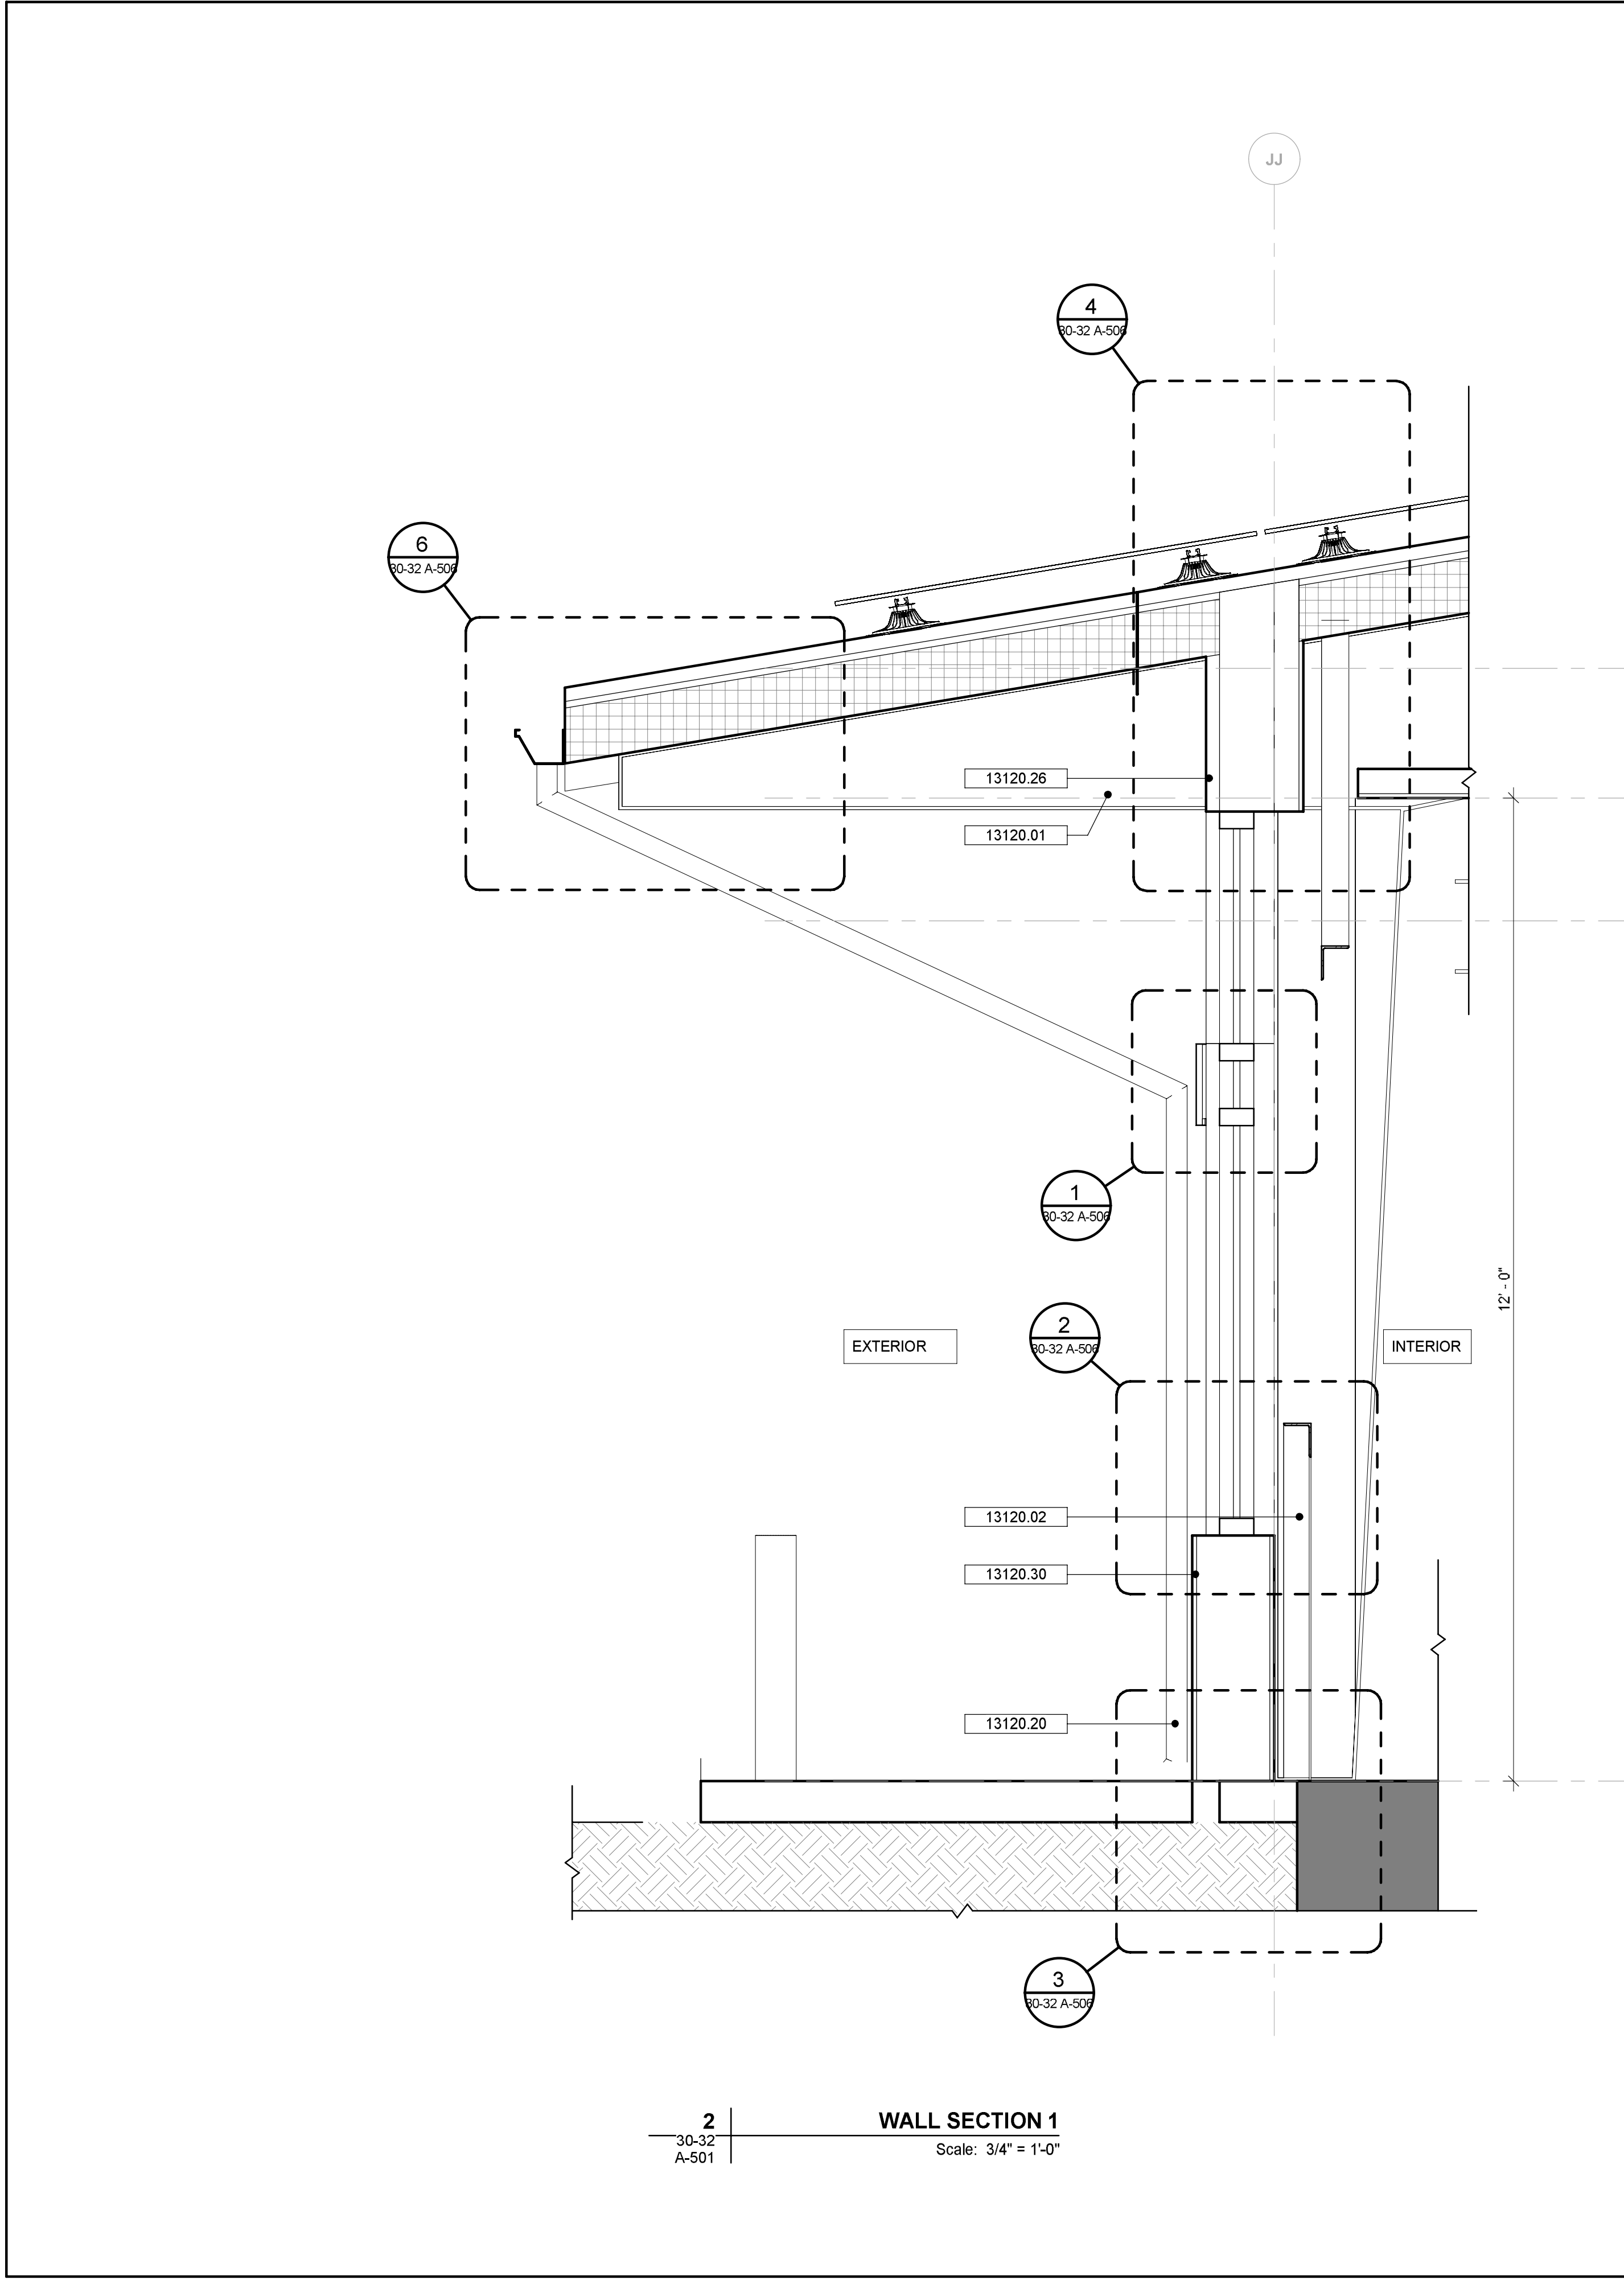

KEYNOTE LEGEND	
KEY VALUE	KEYNOTE TEXT
13120.01	PRE-ENGINEERED METAL STRUCTURE
13120.02	PRE-ENGINEERED METAL STRUCTURE CROSS BRACING
13120.19	FACTORY FINISHED GUTTER
13120.20	FACTORY FINISHED DOWNSPOUT
13120.26	METAL PANEL RIBBED ON 8" GIRTS, INSULATED, VAPOR RETARDER
13120.30	METAL PANEL WAVE ON 8" GIRTS, INSULATED, VAPOR RETARDER

PROJECT

GRAHAM HILL WATER
TREATMENT PLANT - FACILITY
IMPROVEMENTS PROJECT

715 Graham Hill Rd,
Santa Cruz, CA 95060
APN 060-141-05

OWNER

**CITY OF SANTA CRUZ
WATER DEPARTMENT**

212 Locust St Ste A
Santa Cruz, CA 95060
PHONE: (831) 420-5200



ENGINEER

AECOM TECHNICAL SERVICES, INC.
250 APOLLO DRIVE
CHELMSFORD, MA 01824
PHONE: (978) 905-2100
www.aecom.com

AECOM TECHNICAL SERVICES, INC.
2020 L STREET
SACRAMENTO, CA 95811
PHONE: (916) 414-5800
www.aecom.com

CONSULTANTS

KENNEDY JENKS (Design assistance)
275 Battery Street, Suite 550
San Francisco, CA 94111
www.kennedyjenks.com

BOWMAN & WILLIAMS (Surveyor)
3949 Research Park Court, Suite 100
Soquel, CA 95073
www.bowmanandwilliams.com

REGISTRATION



ISSUE/REVISION

I/R	DATE	DESCRIPTION

PROJECT NUMBER

60667213

Designed By:	W. GORYL
Drawn By:	M. PICONE
Dept Check:	G. OTTERSON
Approved by:	G. PERIGAULT
Date:	DECEMBER 2023
Scale:	3/4" = 1'-0"

DISCIPLINE


ARCHITECTURAL
SHEET TITLE

**ADMIN & OPS BUILDING -
WALL SECTIONS 1**

SHEET NUMBER

30-32 A-501 PAGE 24 OF 27

PATH\\FLEN\\AECOM\\Autodesk Docs\\60667213-GH\\WTP_FIP\\85-A-Maintenance Building.rvt
LAST UPDATE: 12/13/2023 11:27:44 AM
PLOT DATE: 12/13/2023 11:27:44 AM

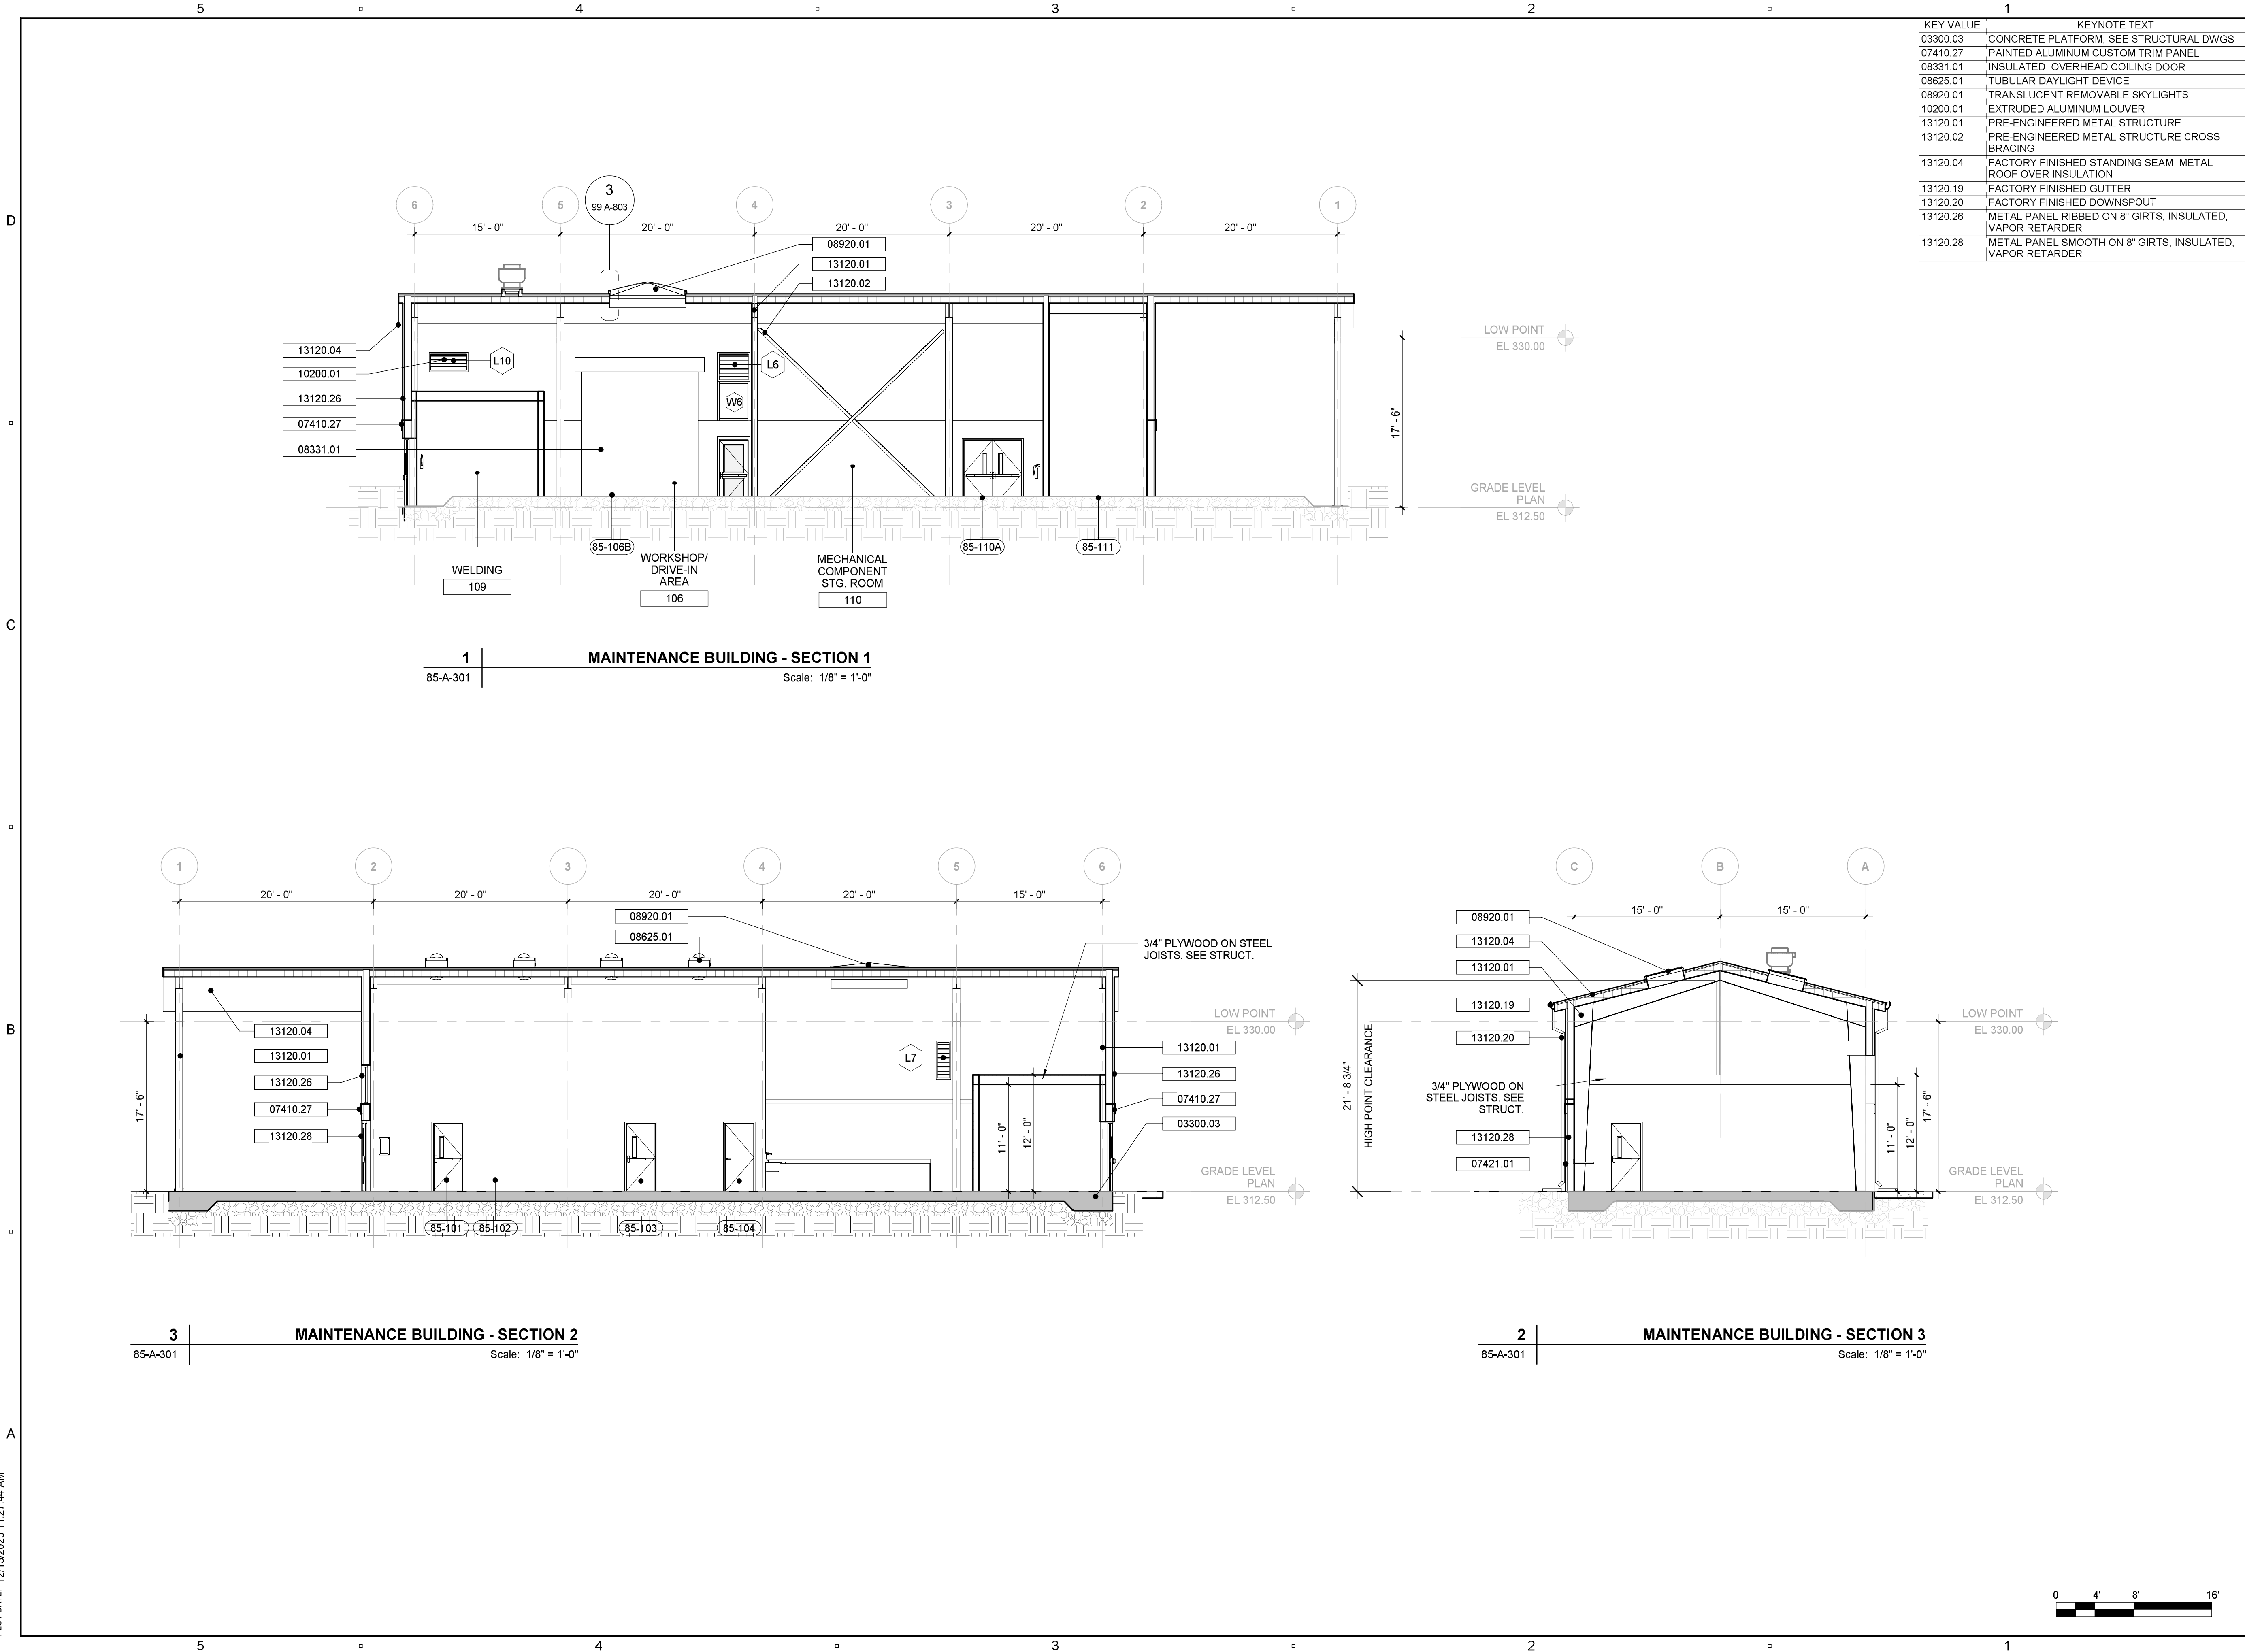

PROJECT

GRAHAM HILL WATER
TREATMENT PLANT - FACILITY
IMPROVEMENTS PROJECT

715 Graham Hill Rd,
Santa Cruz, CA 95060
APN 060-141-05

OWNER

**CITY OF SANTA CRUZ
WATER DEPARTMENT**

212 Locust St Ste A
Santa Cruz, CA 95060
PHONE: (831) 420-5200



ENGINEER

AECOM TECHNICAL SERVICES, INC.
250 APOLLO DRIVE
CHELMSFORD, MA 01824
PHONE: (978) 905-2100
www.aecom.com

AECOM TECHNICAL SERVICES, INC.
2020 L STREET
SACRAMENTO, CA 95811
PHONE: (916) 414-5800
www.aecom.com

CONSULTANTS

KENNEDY JENKS (Design assistance)
275 Battery Street, Suite 550
San Francisco, CA 94111
www.kennedyjenks.com

BOWMAN & WILLIAMS (Surveyor)
3949 Research Park Court, Suite 100
Soquel, CA 95073
www.bowmanandwilliams.com

REGISTRATION



ISSUE/REVISION

IR	DATE	DESCRIPTION

PROJECT NUMBER

60667213
Designed By: M. PICONE
Drawn By: M. PICONE
Dept Check: W. GORYL
Approved by: G. PERIGAULT
Date: DECEMBER 2023
Scale: 1/8" = 1'-0"

DISCIPLINE
ARCHITECTURAL
SHEET TITLE

**MAINTENANCE
BUILDING - SECTIONS**

SHEET NUMBER

85-A-301 PAGE 25 OF 27

